

Enabel - Belgian Development Agency



PUBLIC WORKS CONTRACT FOR THE DEVELOPMENT OF SEMI-PUBLIC SPACES IN EAST JERUSALEM

Reference No.: PZA170421T-10029

Funded By



Designed by




Jerusalem - Sheikh Jarrah- Tobler8

July 2023


1. Architectural Drawings

A01	Existing Floor Plans
A02	Demolishing Plans
A03	Furniture Plans
A04	Dimension Plans
A05	Ceiling Plans
A06	Details
A07	Furniture Details
A08	Door & Window Table


Photos of current situation

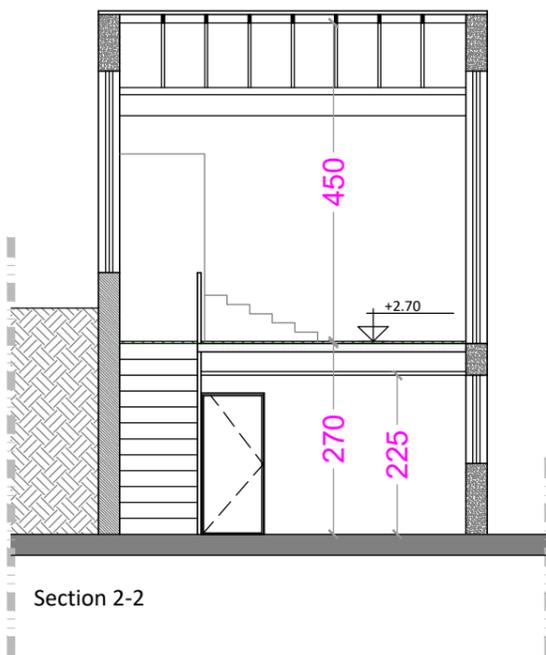


Section 2-2

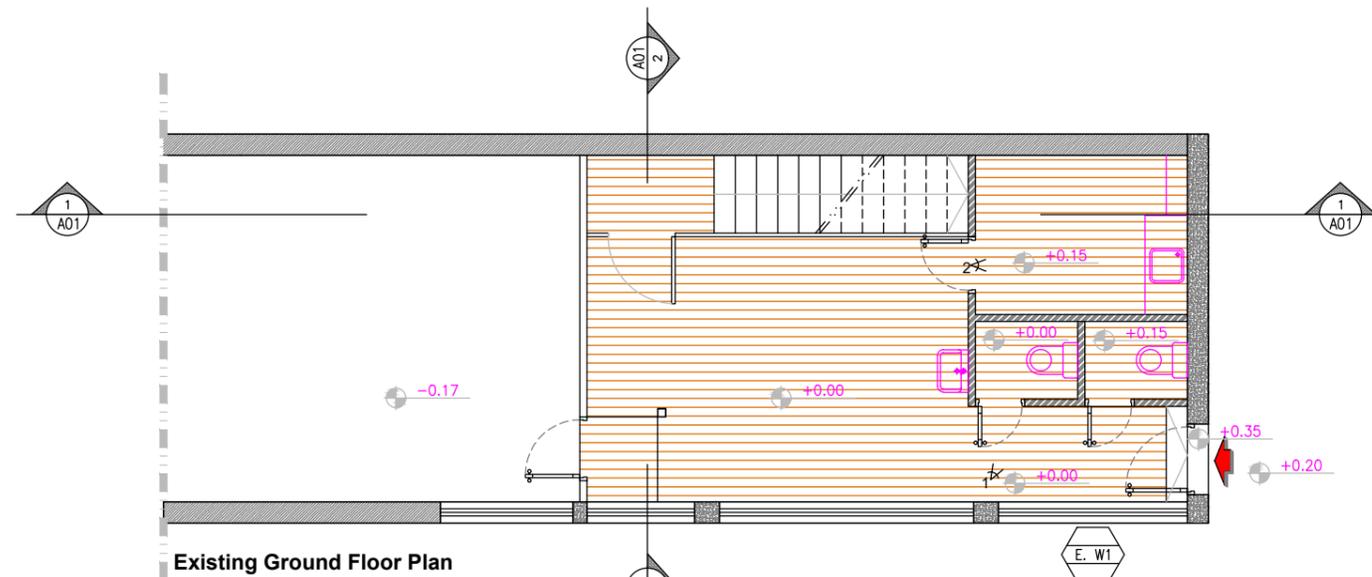

Existing Ground Floor Plan

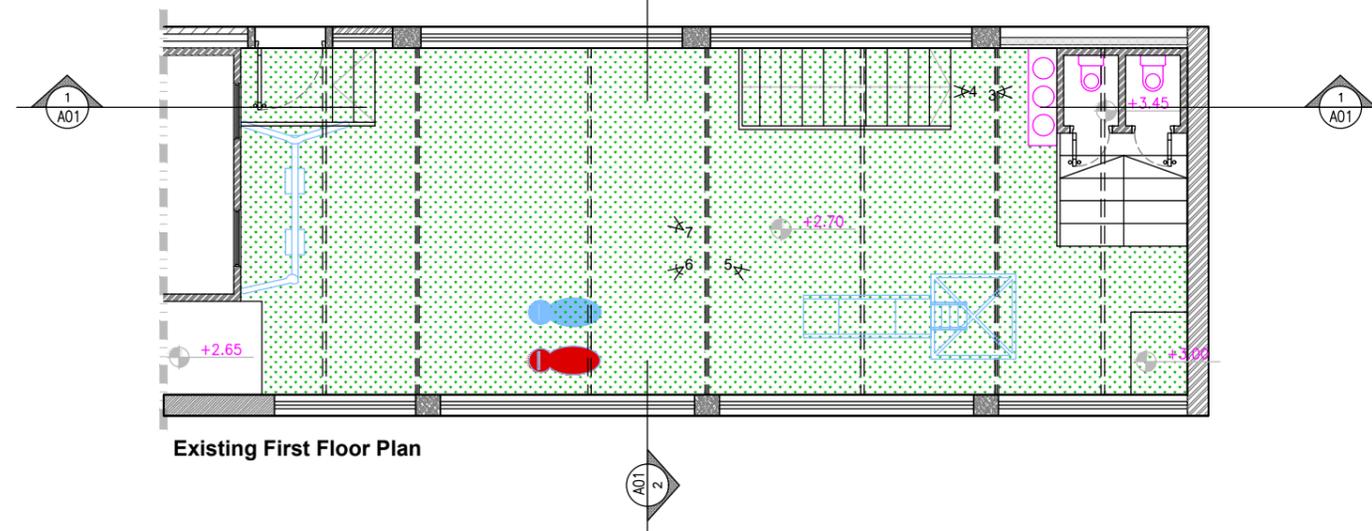

Existing First Floor Plan

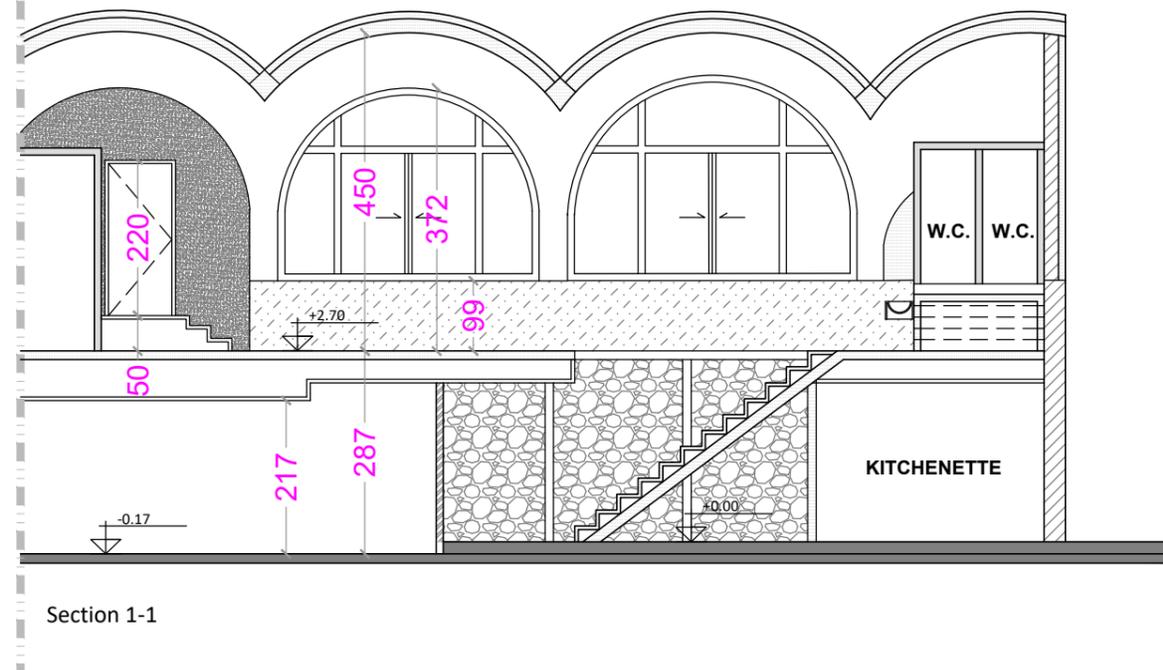

Section 1-1

Notes

- (1) All Dimensions Are In M.
- (2) All Levels Are In Meter
- (3) Any Missing or Unclear Detail And All Fastening Systems For All Elements Shall be Approved by The Supervisor.

Legend:

	SECTION NUMBER REFERENCE SHEET NUMBER		ROOM CODE FUNCTION AREA
	REFERENCE DETAIL SHEET NUMBER		ROOM ID
	FLOOR FINISH LEVEL (F.F.L.)		DOOR NUMBER REFERENCE DETAIL SHEET NUMBER
	REINFORCEMENT CONCRETE LEVEL (R.C.L.)		WINDOW NUMBER REFERENCE DETAIL SHEET NUMBER
	LEVEL SIGN IN PLAN		DETAILED SECTION AT SHEET No. A09
	STEEL SHEETS		ENTRANCE
	RC CONCRETE FOR COLUMNS		ARTIFICIAL GRASS
	RC CONCRETE FOR WALLS		PORCELAIN TILES (PARQUET STYLE)
	CONCRETE		PORCELAIN TILES (PARQUET STYLE)
	STONE WALL		BITUMINOUS MEMBRANE LAYER
	HOLLOW BLOCKS		
	CEMENT TILE		
	PORCELAIN TILE		R.C.L.-REN. CONCRETE LEVEL
	LOCAL MARBLE		F.F.L.-FINISH FLOOR LEVEL
	Gypsum partition		S.L.: SEA LEVEL

REVISIONS

NO.	DRAWINGS	DATE
(1)		
(2)		
(3)		

Contracting Authority:

Enabel - Belgian Development Agency



Funded By:

This Project is Funded by



Project Title:

Public services contract for "Participatory design and supervision of Public and Semi-Public spaces in East Jerusalem / Silwan neighborhood"


Reference No.: PZA170421T-10028

Designed by:




Jerusalem - Sheikh Jarrah- Tobler8
email: mr.wasimhija@gmail.com
Tel. 02-9948344/ 052-8327076
Fax: 02-9948344

Drawing Title	Existing Floor Plans	Date: 28/3/2023 Scale: 1:100
Designed by:	Arch. Hiba Al Ayoubi	Drawing No:
Checked by:	Arch. Wasim Abu El-Hija	A01
Approved by:		
Coordinate Manager:		

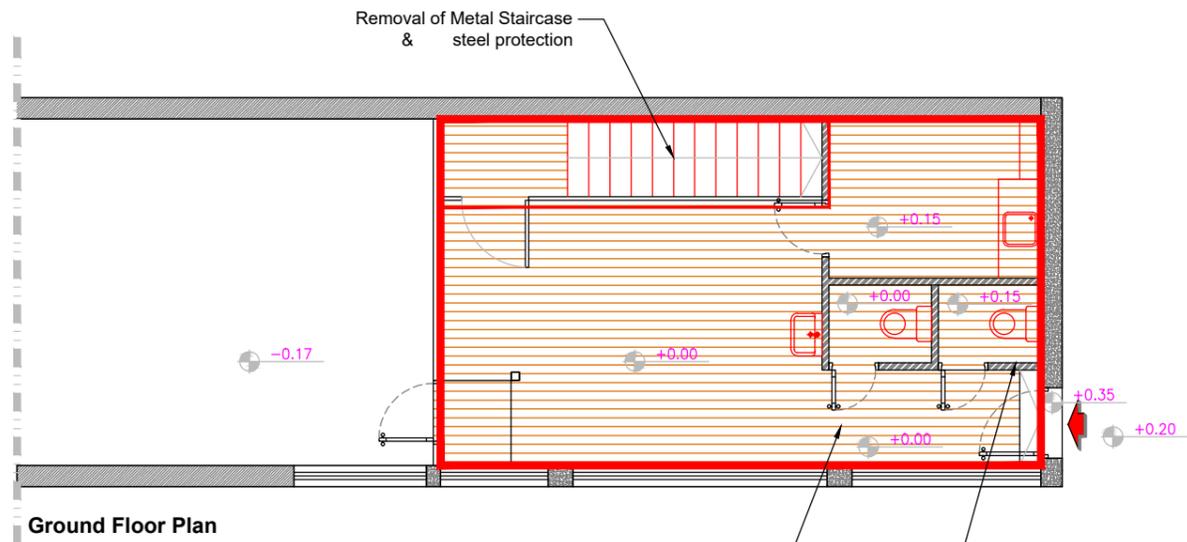


Ground Floor Plan

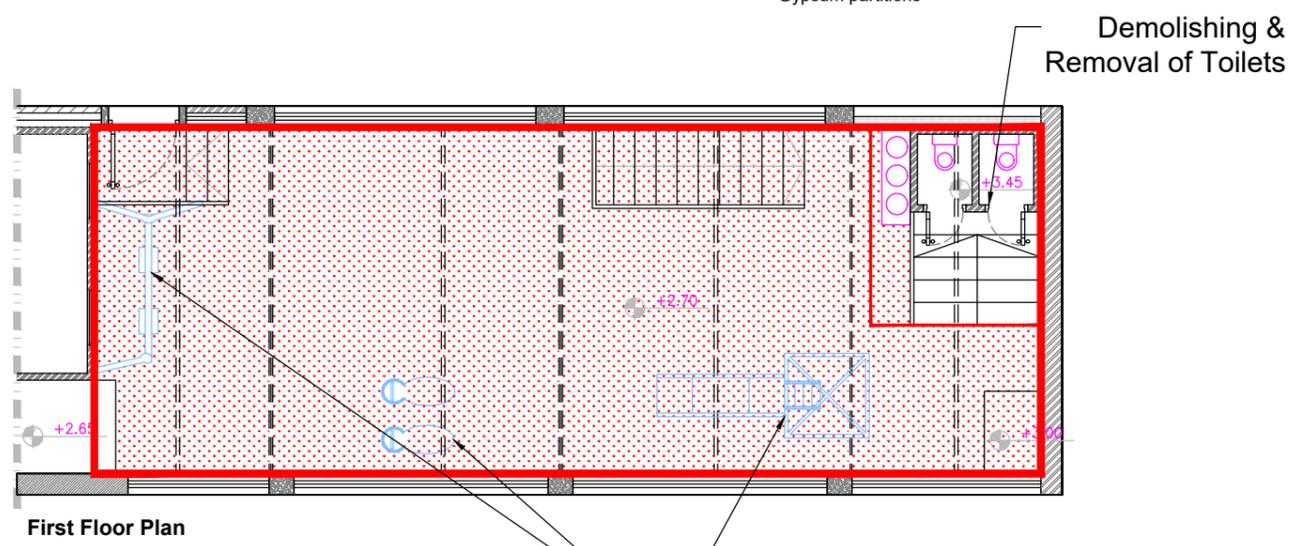

First Floor Plan

Removal all kids equipments and artificial grass removal based on the engineer

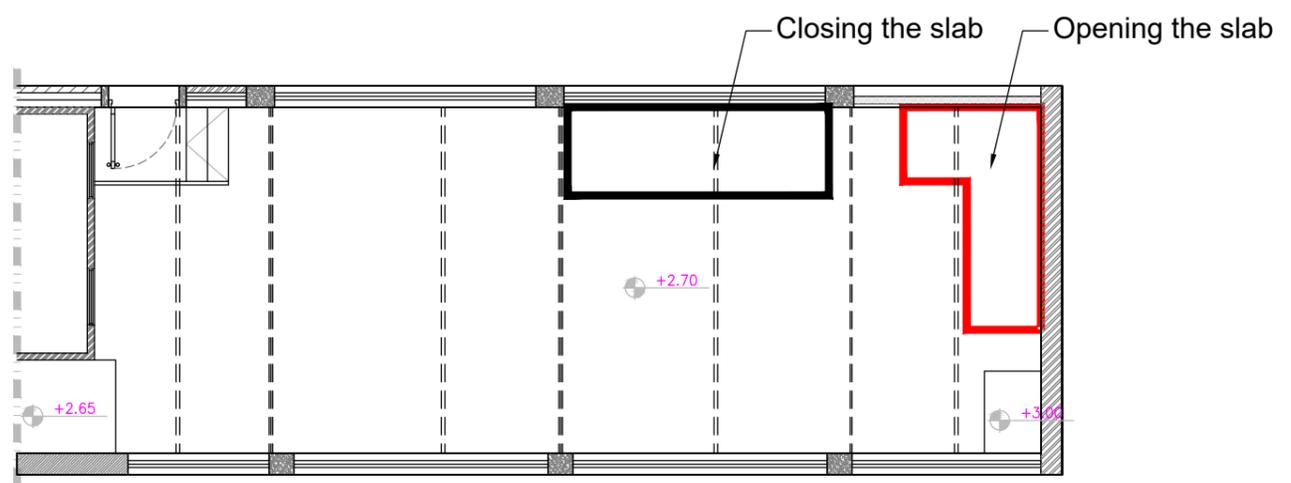

First Floor Plan

Notes

- (1) All Dimensions Are In M.
- (2) All Levels Are In Meter
- (3) Any Missing or Unclear Detail And All Fastening Systems For All Elements Shall be Approved by The Supervisor.

Legend:

SECTION NUMBER	ROOM CODE	FUNCTION AREA
REFERENCE SHEET NUMBER	ROOM ID	
REFERENCE DETAIL SHEET NUMBER	DOOR NUMBER	REFERENCE DETAIL SHEET NUMBER
FLOOR FINISH LEVEL (F.F.L.)	REINFORCEMENT CONCRETE LEVEL (R.C.L.)	WINDOW NUMBER
LEVEL SIGN IN PLAN	DETAILED SECTION AT SHEET No. A09	
STEEL SHEETS	RC CONCRETE FOR COLUMNS	ENTRANCE
RC CONCRETE FOR WALLS	CONCRETE	ARTIFICIAL GRASS
STONE WALL	HOLLOW BLOCKS	PORCELAIN TILES (PARQUET STYLE)
CEMENT TILE	PORCELAIN TILE	DEMOLISHING AND REMOVAL
LOCAL MARBLE	Gypsum partition	NEW INTERVENTION
R.C.L.-REN. CONCRETE LEVEL	F.F.L.-FINISH FLOOR LEVEL	
S.L. : SEA LEVEL		

REVISIONS		
NO.	DRAWINGS	DATE
(1)		
(2)		
(3)		

Contracting Authority:
Enabel - Belgian Development Agency



Funded By:

This Project is Funded by

EUROPEAN UNION

Project Title:
Public services contract for "Participatory design and supervision of Public and Semi-Public spaces in East Jerusalem / Silwan neighborhood"
Reference No.: PZA170421T-10028

Designed by:

Jerusalem - Sheikh Jarrah- Tobler8
email: mr.wasimhija@gmail.com

Tel. 02-9948344/ 052-8327076
Fax: 02-9948344

Drawing Title	Demolishing Plans	Date: 28/3/2023
		Scale: 1:100
Designed by:	Arch. Hiba Al Ayoubi	Drawing No:
Checked by:	Arch. Wasim Abu El-Hija	A02
Approved by:		
Coordinate Manager:		



1



2




3




5



4

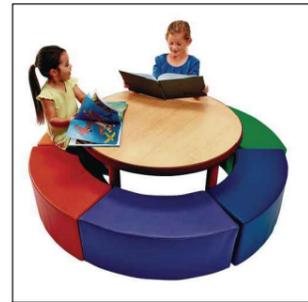




6

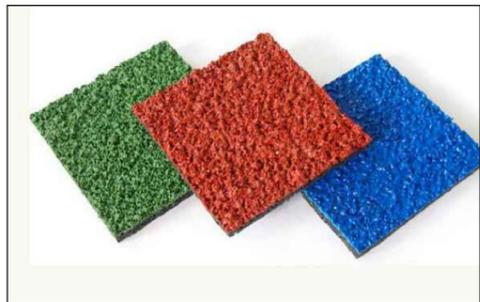

7



8

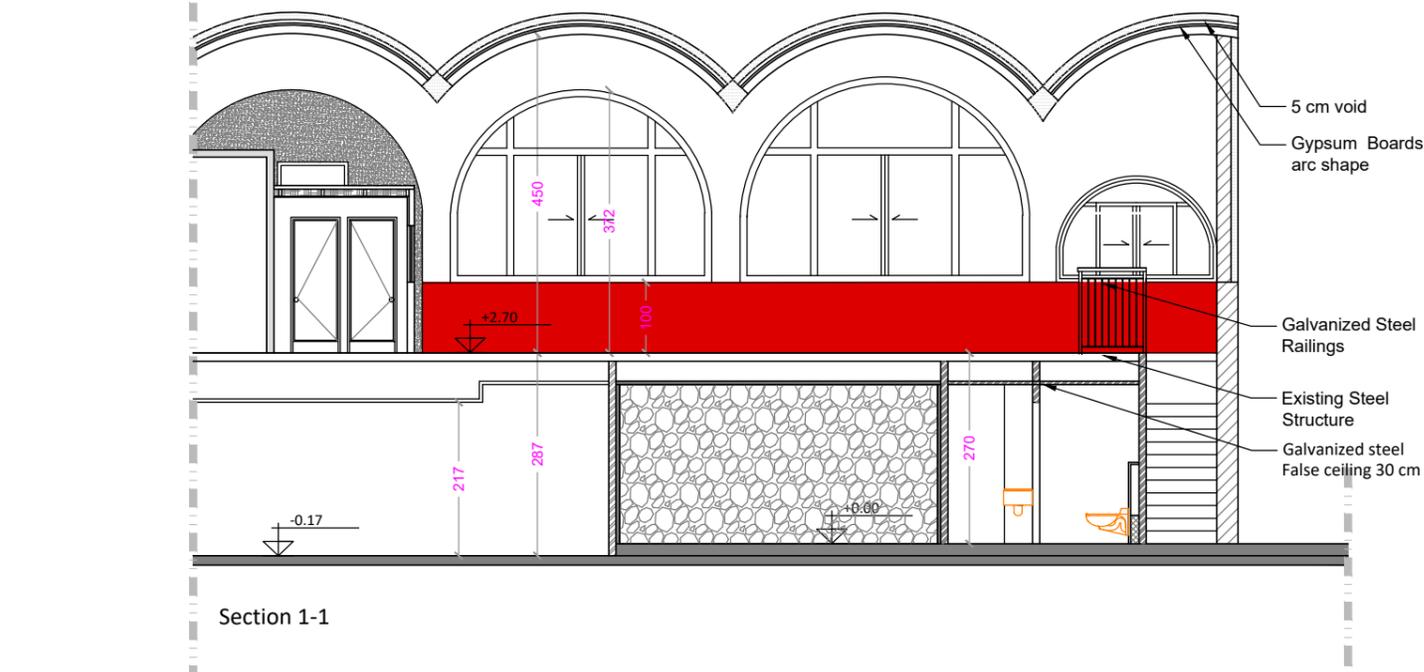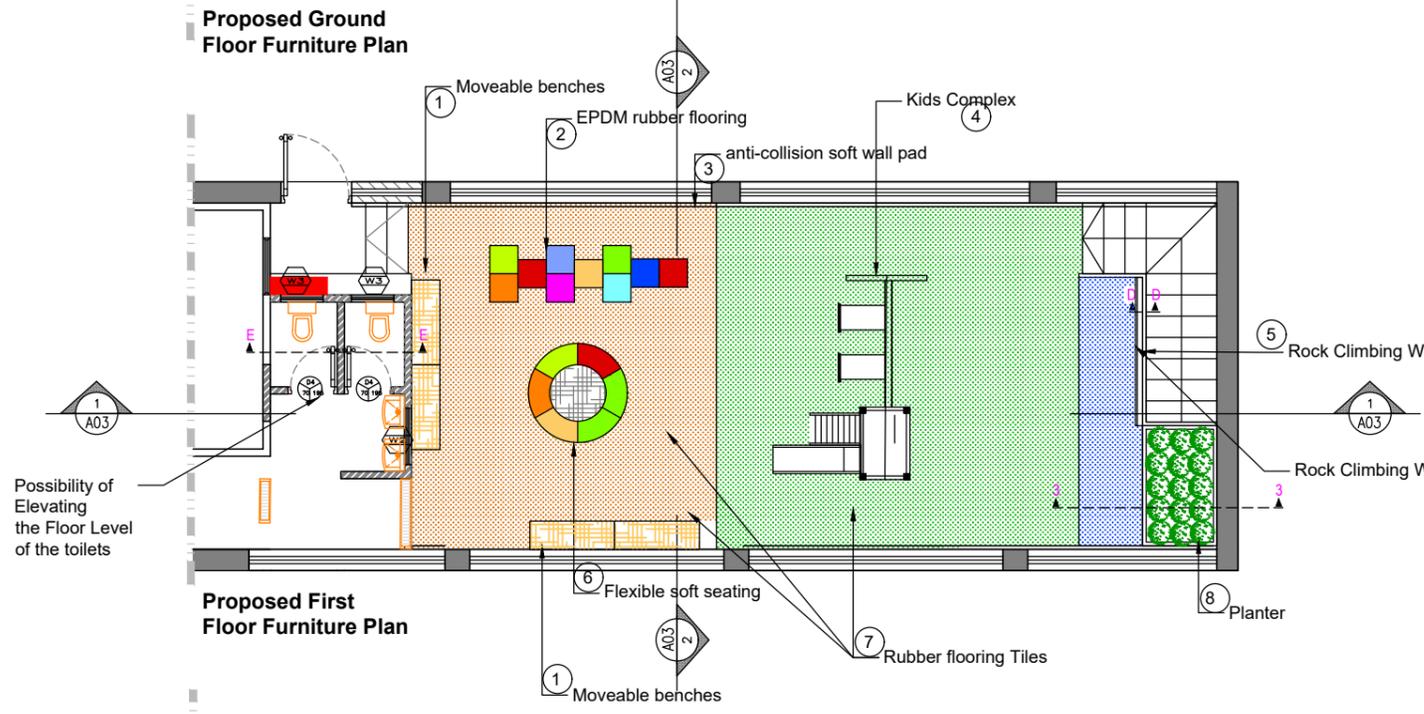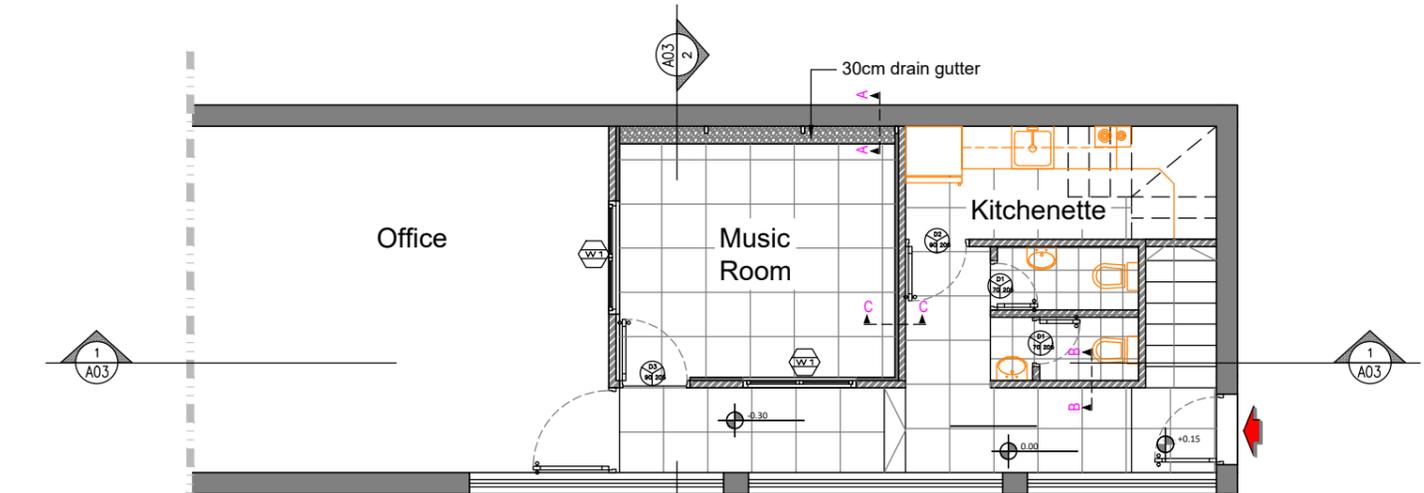

Notes
 (1) All Dimensions Are In M.
 (2) All Levels Are In Meter
 (3) Any Missing or Unclear Detail And All Fastening Systems For All Elements Shall be Approved by The Supervisor.

Legend:

	SECTION NUMBER REFERENCE SHEET NUMBER		ROOM CODE FUNCTION AREA ROOM ID
	REFERENCE DETAIL SHEET NUMBER		DOOR NUMBER REFERENCE DETAIL SHEET NUMBER
	FLOOR FINISH LEVEL (F.F.L.) REINFORCEMENT CONCRETE LEVEL (R.C.L.)		WINDOW NUMBER REFERENCE DETAIL SHEET NUMBER
	LEVEL SIGN IN PLAN		ENTRANCE
	STEEL SHEETS		SOUND INSULATION
	RC CONCRETE FOR COLUMNS		PORCELAIN TILES (PARQUET STYLE)
	RC CONCRETE FOR WALLS		
	CONCRETE		
	STONE WALL		
	HOLLOW BLOCKS		
	CEMENT TILE		
	PORCELAIN TILE		
	LOCAL MARBLE		
	Gypsum partition		
	R.C.L.-REN. CONCRETE LEVEL		
	F.F.L.-FINISH FLOOR LEVEL		
	S.L.: SEA LEVEL		

REVISIONS

NO.	DRAWINGS	DATE
(1)		
(2)		
(3)		

Contracting Authority:
 Enabel - Belgian Development Agency

Funded By:

This Project is Funded by
 EUROPEAN UNION

Belgium
 partner in development

Project Title:
 Public services contract for "Participatory design and supervision of Public and Semi-Public spaces in East Jerusalem / Silwan neighborhood"
 Reference No.: PZA170421T-10028

Designed by:

HOSH STUDIO
 ARCHITECTURE & TOWN PLANNING

Jerusalem - Sheikh Jarrah- Tobler8
 email: mr.wasimhija@gmail.com
 Tel. 02-9948344/ 052-8327076
 Fax: 02-9948344

Drawing Title	Furniture Plans	Date: 28/3/2023
Designed by:	Arch. Hiba Al Ayoubi	Scale: 1:100
Checked by:	Arch. Wasim Abu El-Hija	Drawing No: A03
Approved by:		
Coordinate Manager:		

Notes

- (1) All Dimensions Are In M.
- (2) All Levels Are In Meter
- (3) Any Missing or Unclear Detail And All Fastening Systems For All Elements Shall be Approved by The Supervisor.

Legend:

	SECTION NUMBER		ROOM CODE
	REFERENCE SHEET NUMBER		FUNCTION AREA
	REFERENCE DETAIL SHEET NUMBER		ROOM ID
	FLOOR FINISH LEVEL (F.F.L.)		DOOR NUMBER
	REINFORCEMENT CONCRETE LEVEL (R.C.L.)		REFERENCE DETAIL SHEET NUMBER
	LEVEL SIGN IN PLAN		WINDOW NUMBER
	STEEL SHEETS		DETAILED SECTION AT SHEET No. A09
	RC CONCRETE FOR COLUMNS		ENTRANCE
	RC CONCRETE FOR WALLS		SOUND INSULATION
	CONCRETE		PORCELAIN TILES (PARQUET STYLE)
	STONE WALL		
	HOLLOW BLOCKS		
	CEMENT TILE		
	PORCELAIN TILE		R.C.L.-REN. CONCRETE LEVEL
	LOCAL MARBLE		F.F.L.-FINISH FLOOR LEVEL
	Gypsum partition		S.L.: SEA LEVEL

REVISIONS		
NO.	DRAWINGS	DATE
(1)		
(2)		
(3)		

Contracting Authority:
Enabel - Belgian Development Agency

Funded By:

Belgium
partner in development

Project Title:
Public services contract for "Participatory design and supervision of Public and Semi-Public spaces in East Jerusalem / Silwan neighborhood"

Reference No.: PZA170421T-10028







Designed by:


HOSH STUDIO
ARCHITECTURE & TOWN PLANNING

Jerusalem - Sheikh Jarrah- Tobler8
email: mr.wasimhija@gmail.com


Tel. 02-9948344/ 052-8327076
Fax: 02-9948344

Drawing Title	Ceiling Plans	Date: 28/3/2023
Designed by:	Arch. Hiba Al Ayoubi	Scale: 1:100
Checked by:	Arch. Wasim Abu El-Hija	Drawing No: A05
Approved by:		
Coordinate Manager:		

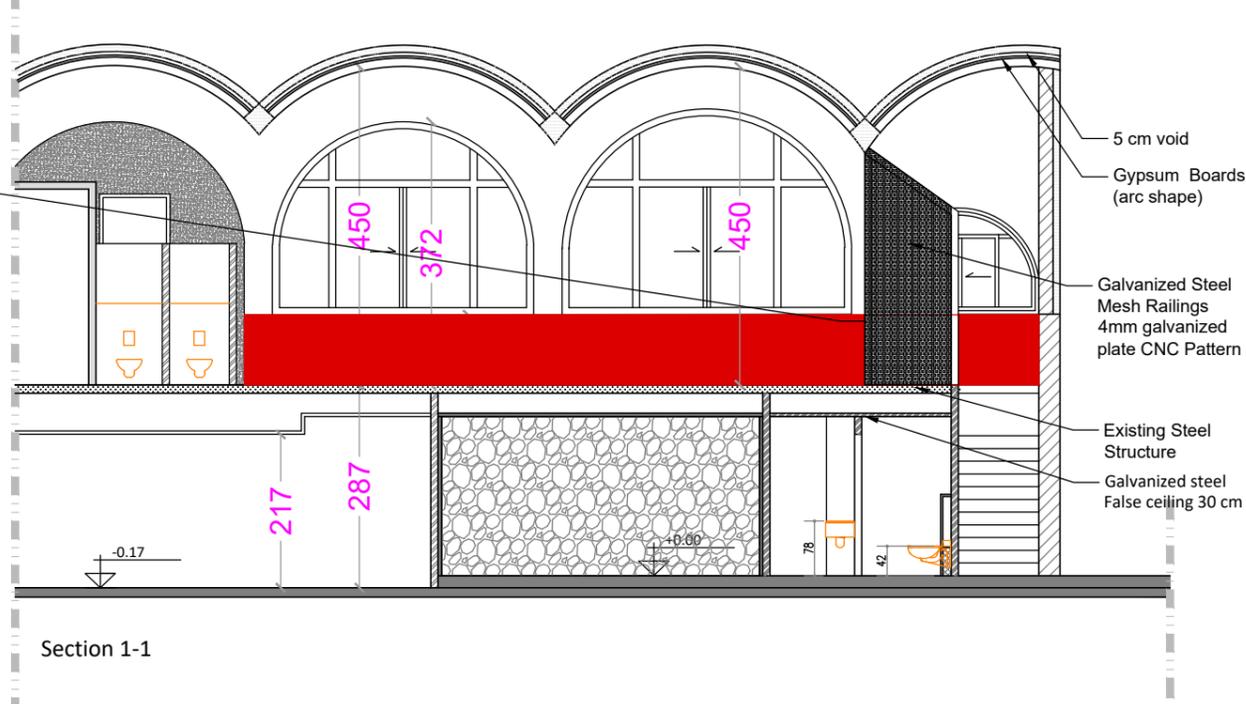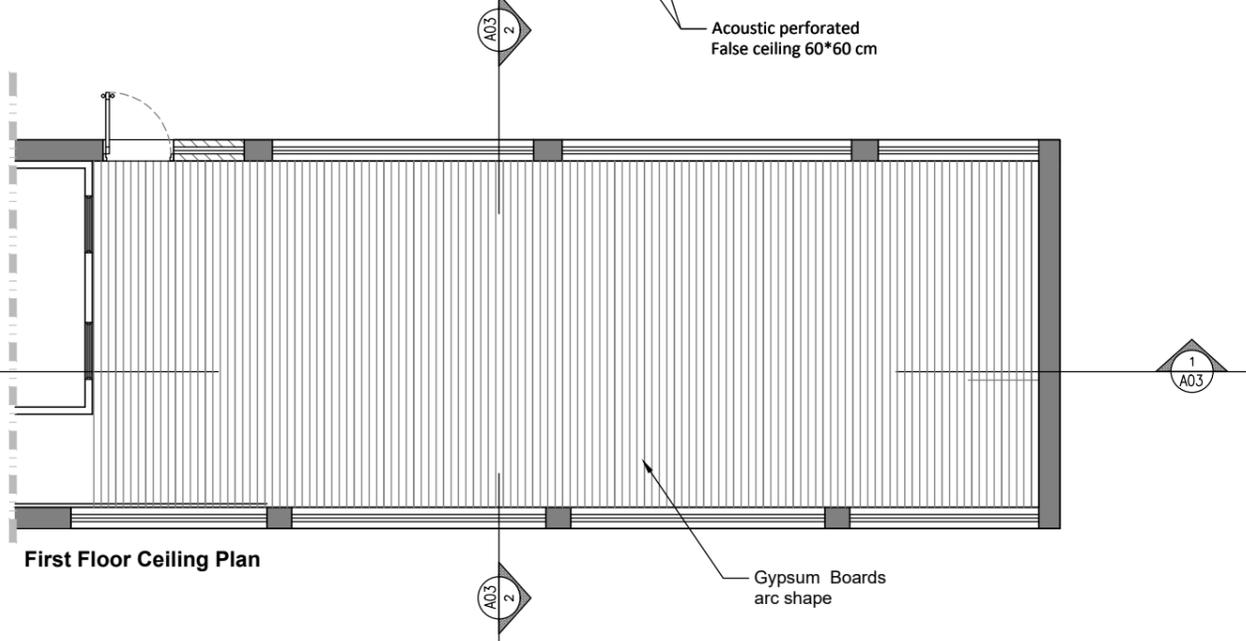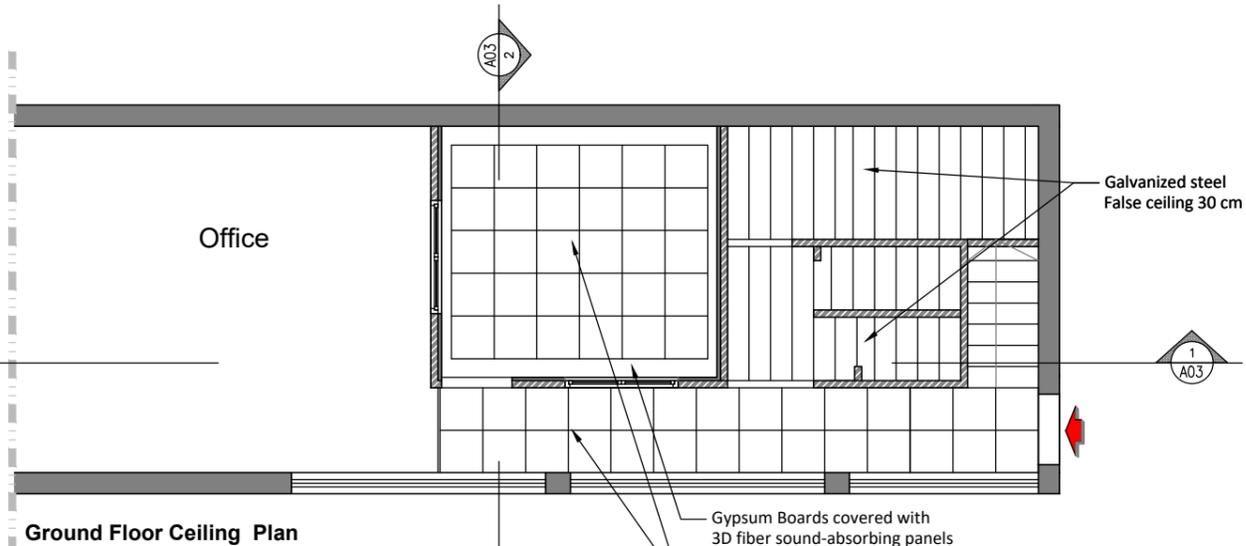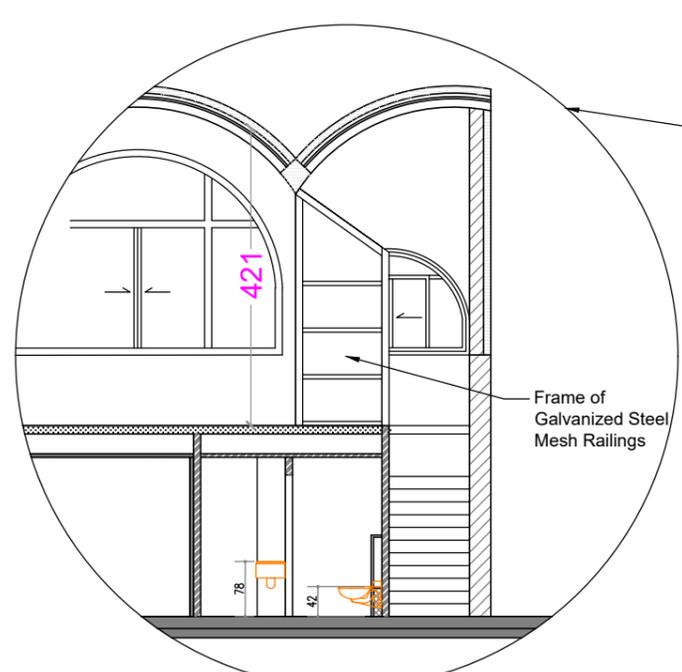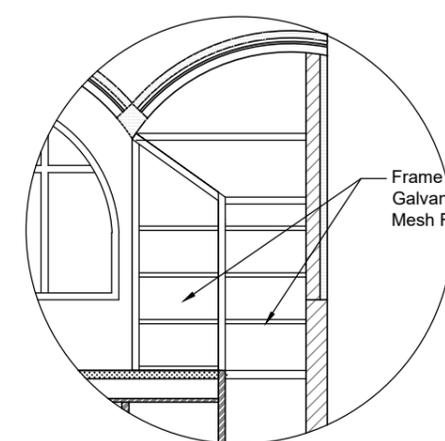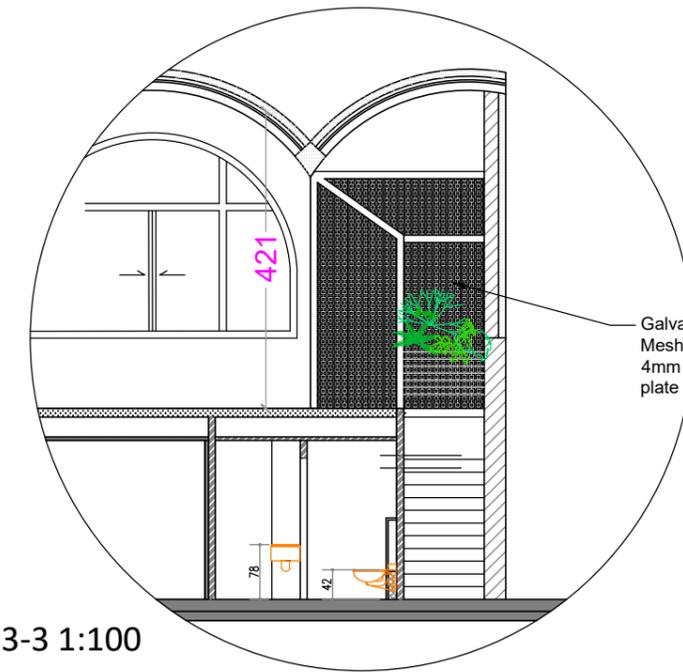


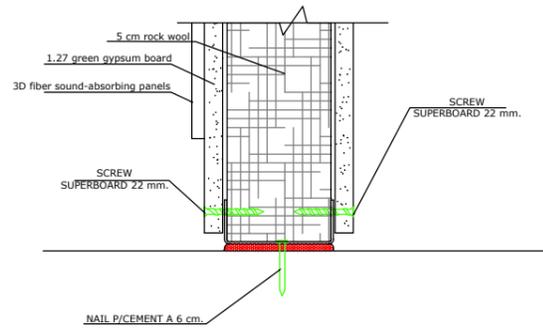


Section C-C 1:10

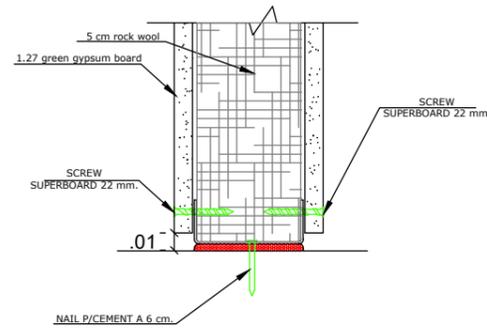

Section B-B 1:10

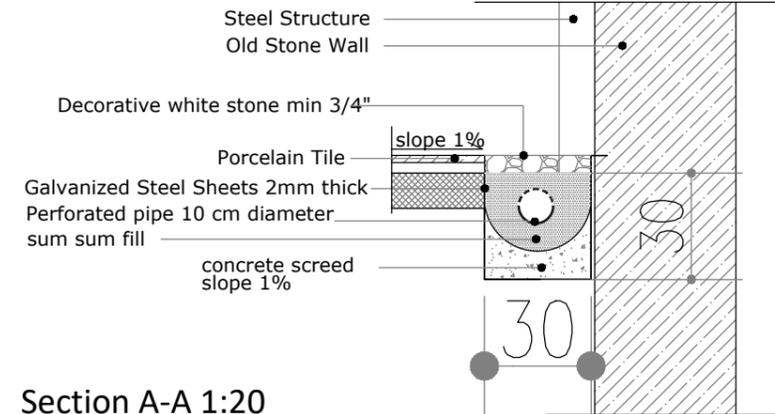

Section A-A 1:20

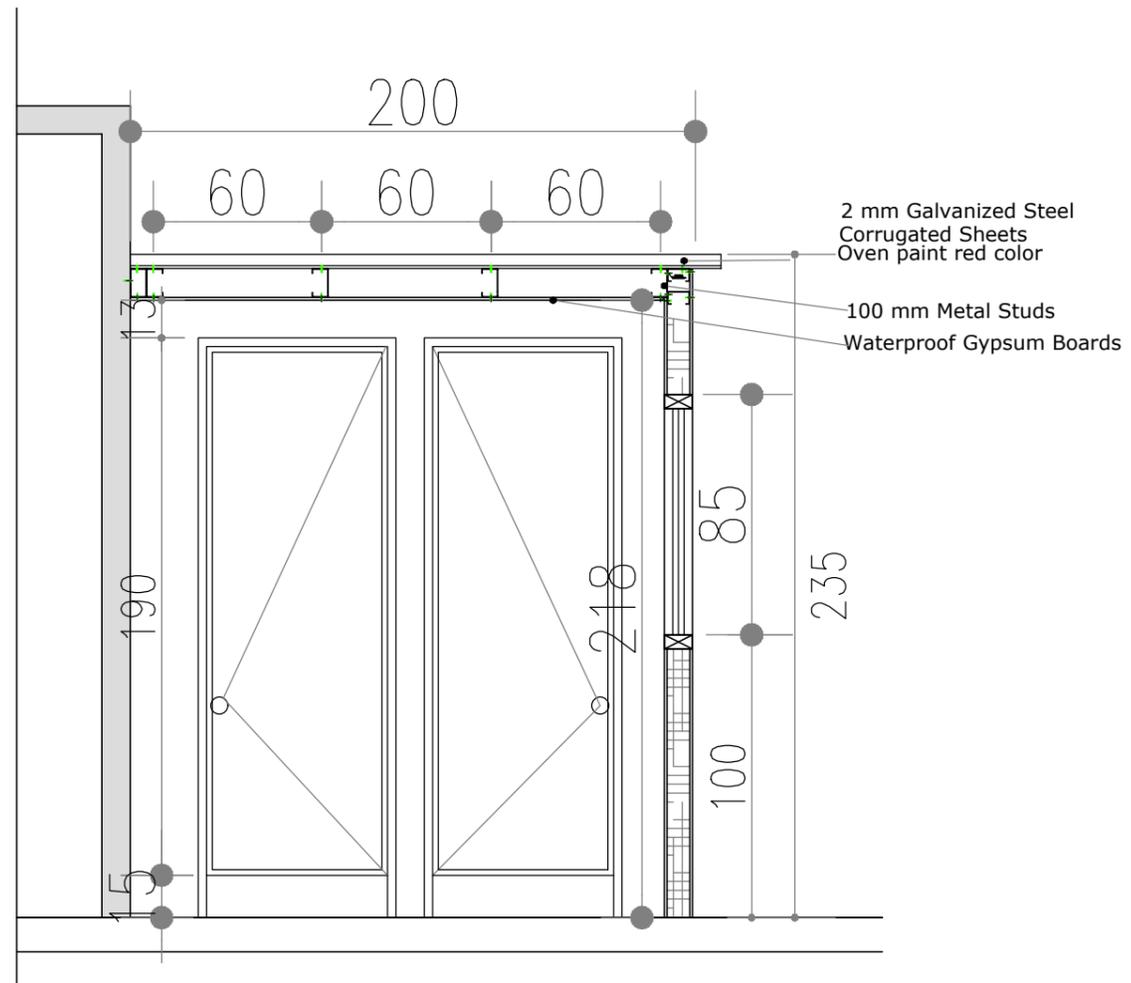

Section E-E 1:25

Notes

- (1) All Dimensions Are In M.
- (2) All Levels Are In Meter
- (3) Any Missing or Unclear Detail And All Fastening Systems For All Elements Shall be Approved by The Supervisor.

Legend:

	SECTION NUMBER		ROOM CODE
	REFERENCE SHEET NUMBER		FUNCTION AREA
	REFERENCE DETAIL SHEET NUMBER		ROOM ID
	FLOOR FINISH LEVEL (F.F.L.)		DOOR NUMBER
	REINFORCEMENT CONCRETE LEVEL (R.C.L.)		REFERENCE DETAIL SHEET NUMBER
	LEVEL SIGN IN PLAN		WINDOW NUMBER
	STEEL SHEETS		REFERENCE DETAIL SHEET NUMBER
	RC CONCRETE FOR COLUMNS		DETAILED SECTION AT SHEET No. A09
	RC CONCRETE FOR WALLS		ENTRANCE
	CONCRETE		SOUND INSULATION
	STONE WALL		PORCELAIN TILES (PARQUET STYLE)
	HOLLOW BLOCKS		THERMAL INSULATION
	CEMENT TILE		
	PORCELAIN TILE		R.C.L.-REN. CONCRETE LEVEL
	LOCAL MARBLE		F.F.L.-FINISH FLOOR LEVEL
	Gypsum partition		S.L. : SEA LEVEL

REVISIONS

NO.	DRAWINGS	DATE
(1)		
(2)		
(3)		

Contracting Authority:

Enabel - Belgian Development Agency



Funded By:



Project Title:

Public services contract for "Participatory design and supervision of Public and Semi-Public spaces in East Jerusalem / Silwan neighborhood"


Reference No.: PZA170421T-10028

Designed by:




Jerusalem - Sheikh Jarrah- Tobler8
 email: mr.wasimhija@gmail.com
 Tel. 02-9948344/ 052-8327076
 Fax: 02-9948344

Drawing Title	Details	Date: 28/3/2023
		Scale: 1:20
Designed by:	Arch. Hiba Al Ayoubi	Drawing No:
Checked by:	Arch. Wasim Abu El-Hija	A06
Approved by:		
Coordinate Manager:		

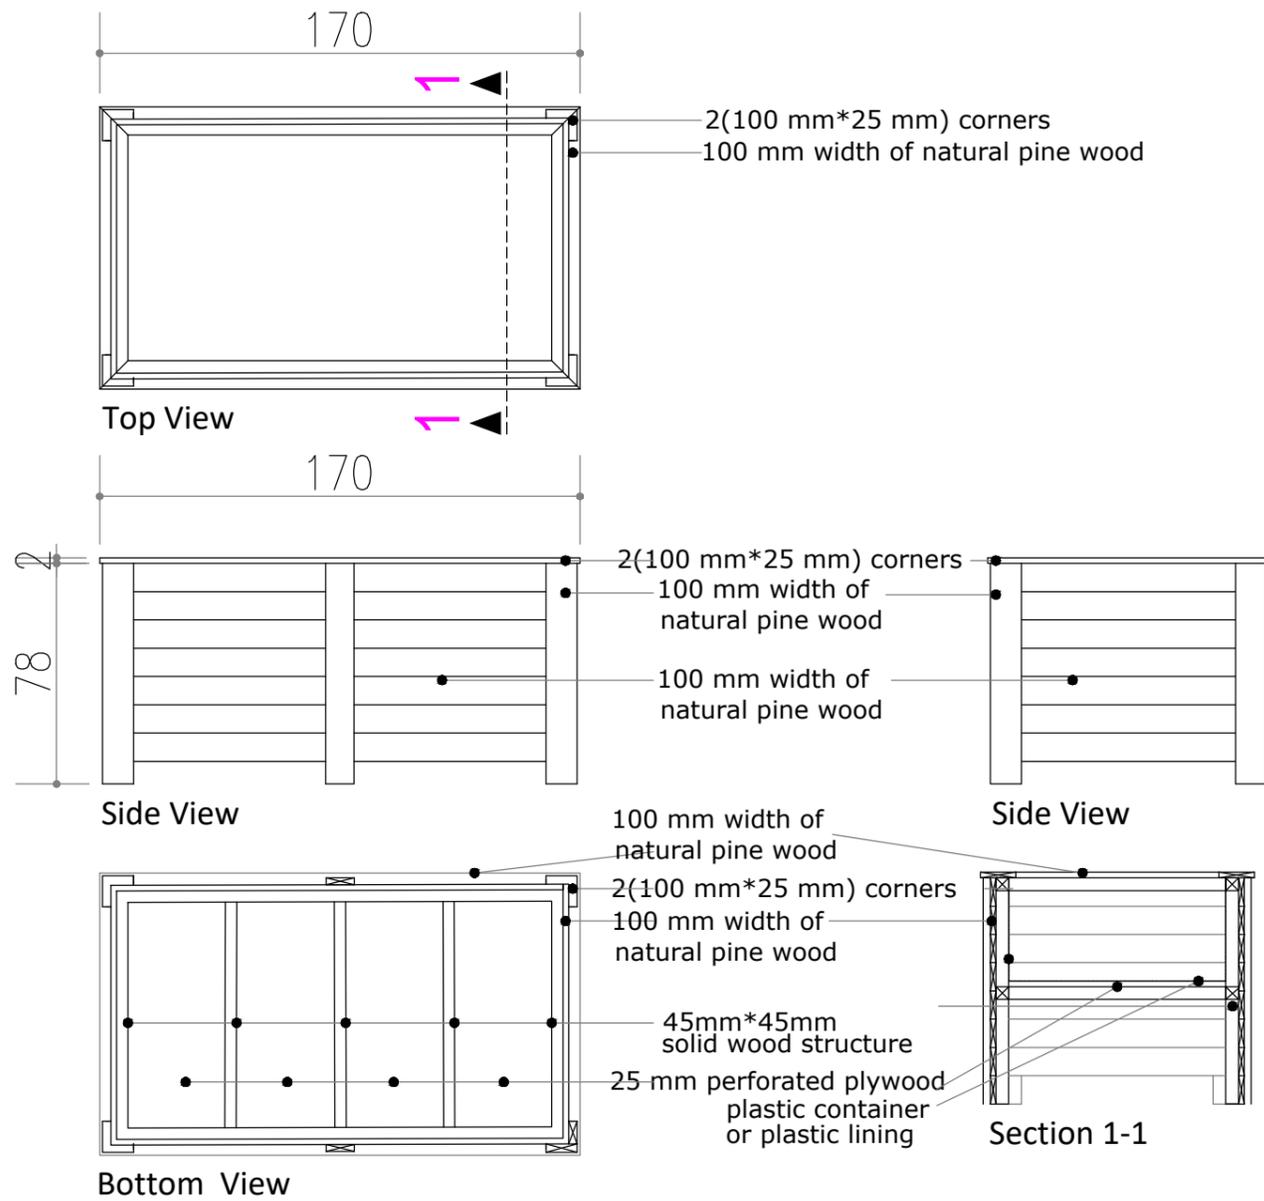

Wooden Planter 1:25

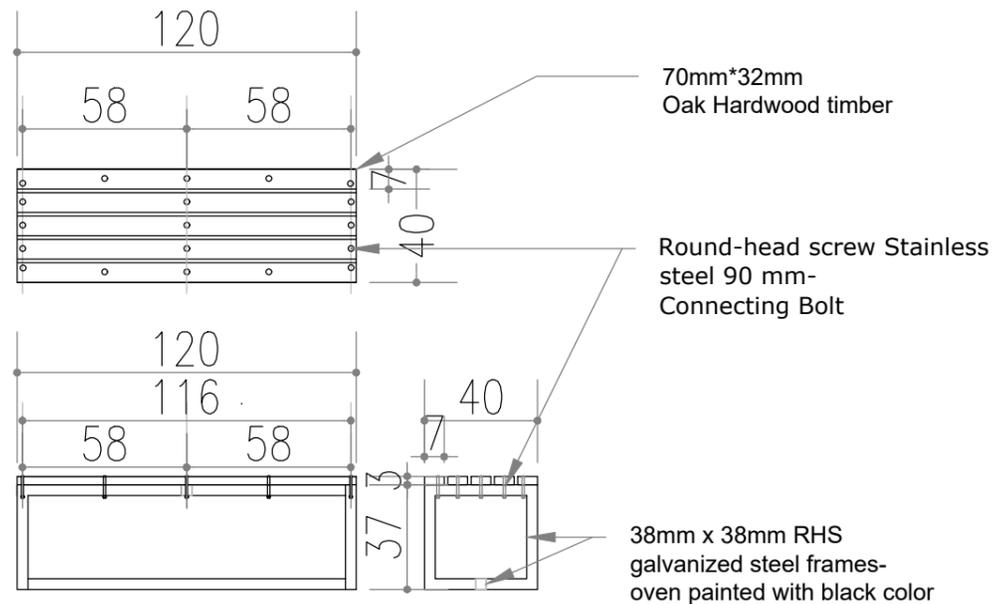

Wooden Bench 1:25

Notes

- (1) All Dimensions Are In M.
- (2) All Levels Are In Meter
- (3) Any Missing or Unclear Detail And All Fastening Systems For All Elements Shall be Approved by The Supervisor.

Legend:

SECTION NUMBER
 REFERENCE SHEET NUMBER
 REFERENCE DETAIL SHEET NUMBER
 FLOOR FINISH LEVEL (F.F.L.)
 REINFORCEMENT CONCRETE LEVEL (R.C.L.)
 LEVEL SIGN IN PLAN
 ROOM CODE
 FUNCTION AREA
 ROOM ID
 DOOR NUMBER
 REFERENCE DETAIL SHEET NUMBER
 WINDOW NUMBER
 REFERENCE DETAIL SHEET NUMBER
 DETAILED SECTION AT SHEET No. A09

STEEL SHEETS
 RC CONCRETE FOR COLUMNS
 RC CONCRETE FOR WALLS
 CONCRETE
 STONE WALL
 HOLLOW BLOCKS
 CEMENT TILE
 PORCELAIN TILE
 LOCAL MARBLE
 Gypsum partition

ENTRANCE
 SOUND INSULATION
 PORCELAIN TILES (PARQUET STYLE)
 THERMAL INSULATION

R.C.L.-REN. CONCRETE LEVEL
 F.F.L.-FINISH FLOOR LEVEL
 S.L.: SEA LEVEL

REVISIONS

NO.	DRAWINGS	DATE
(1)		
(2)		
(3)		

Contracting Authority:

Enabel - Belgian Development Agency



Funded By:



Project Title:

Public services contract for "Participatory design and supervision of Public and Semi-Public spaces in East Jerusalem / Silwan neighborhood"


Reference No.: PZA170421T-10028

Designed by:



Jerusalem - Sheikh Jarrah- Tobler8
 email: mr.wasimhija@gmail.com
 Tel. 02-9948344/ 052-8327076
 Fax: 02-9948344


Drawing Title	Furniture Details	Date: 28/3/2023 Scale: 1:20
Designed by:	Arch. Hiba Al Ayoubi	Drawing No:
Checked by:	Arch. Wasim Abu El-Hija	A07
Approved by:		
Coordinate Manager:		

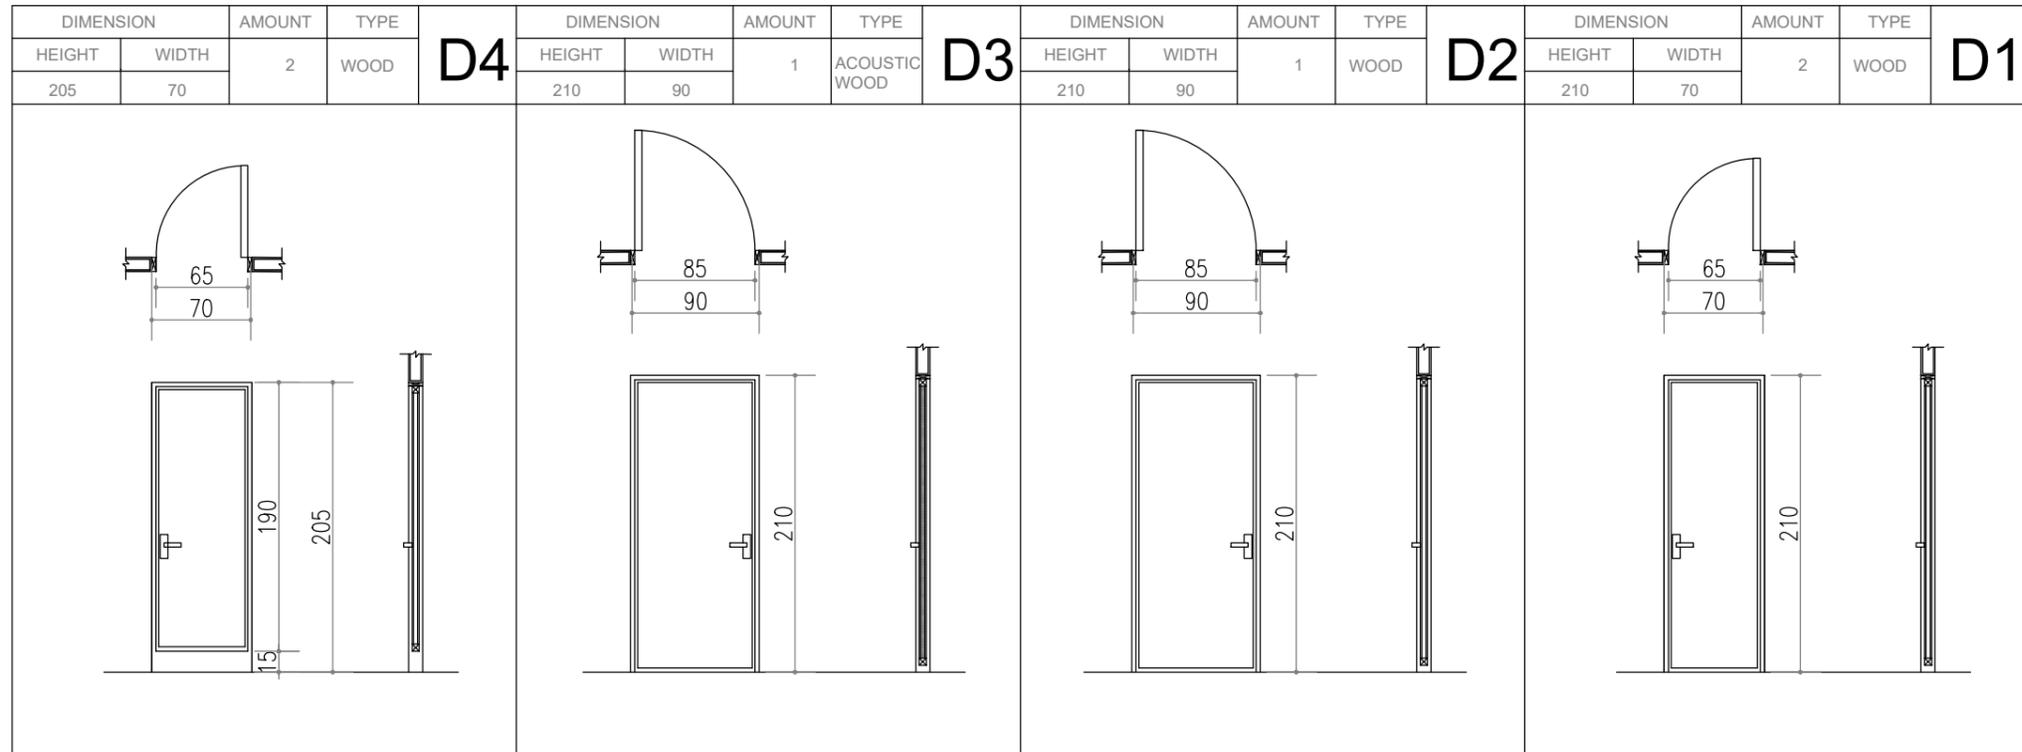

Notes

- (1) All Dimensions Are In M.
- (2) All Levels Are In Meter
- (3) Any Missing or Unclear Detail And All Fastening Systems For All Elements Shall be Approved by The Supervisor.

Legend:

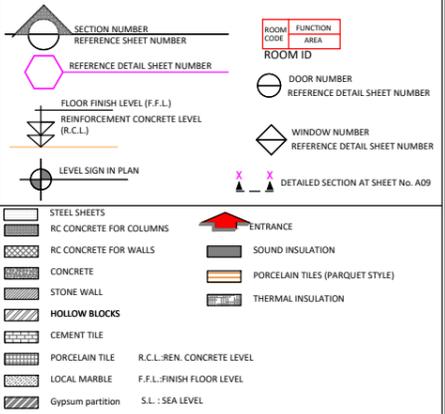

REVISIONS		
NO.	DRAWINGS	DATE
(1)		
(2)		
(3)		

Contracting Authority:
Enabel - Belgian Development Agency




Project Title:
Public services contract for "Participatory design and supervision of Public and Semi-Public spaces in East Jerusalem / Silwan neighborhood"
Reference No.: PZA170421T-10028

Designed by:

HOSH STUDIO
ARCHITECTURE & TOWN PLANNING

Jerusalem - Sheikh Jarrah- Tobler8
email: mr.wasimhija@gmail.com








Tel. 02-9948344/ 052-8327076
Fax: 02-9948344

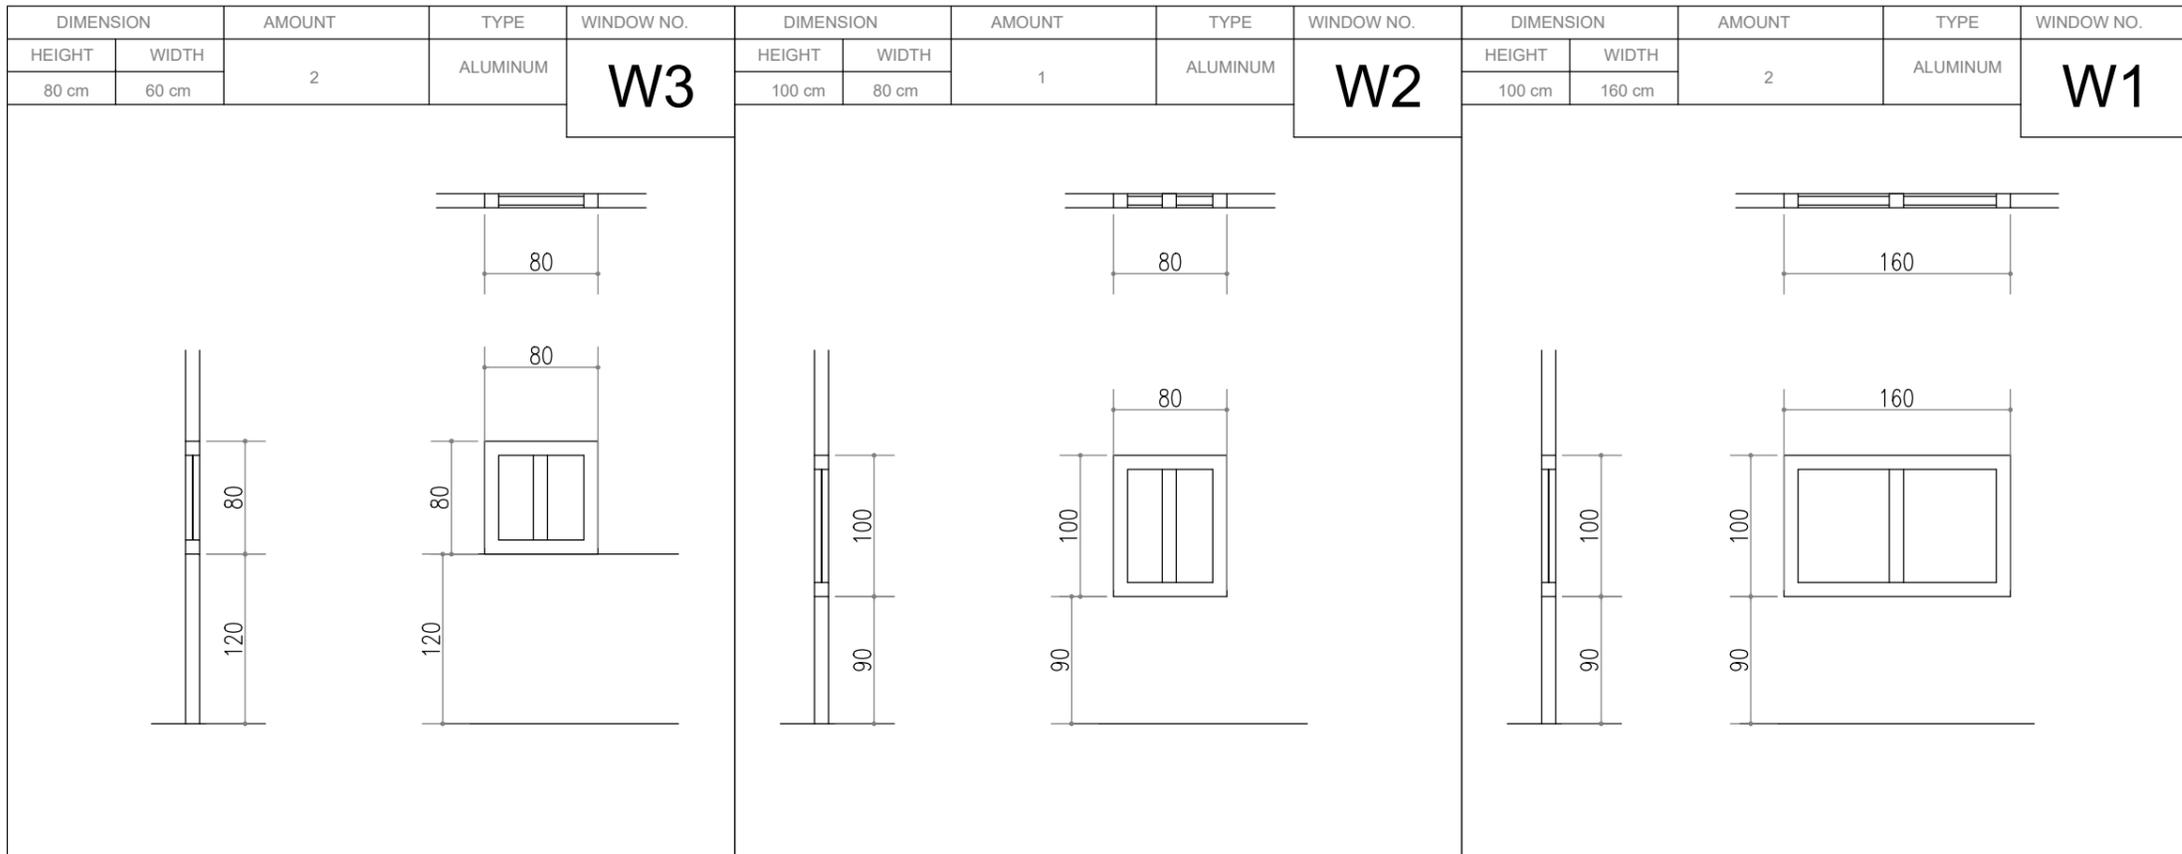

Drawing Title	Door & Window Table	Date: 28/3/2023
		Scale: 1:20
Designed by:	Arch. Hiba Al Ayoubi	A08
Checked by:	Arch. Wasim Abu El-Hija	
Approved by:		
Coordinate Manager:		

2. Structural Drawings

S01	Structural Plan
S02	Steel Staircase Details
S03	Climbing Board Detail

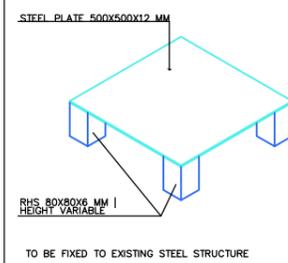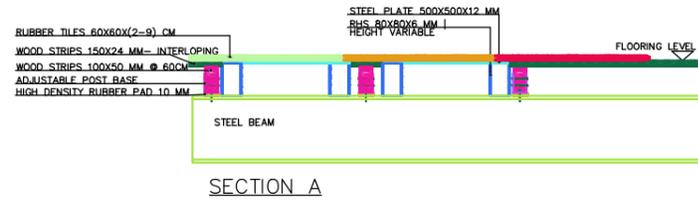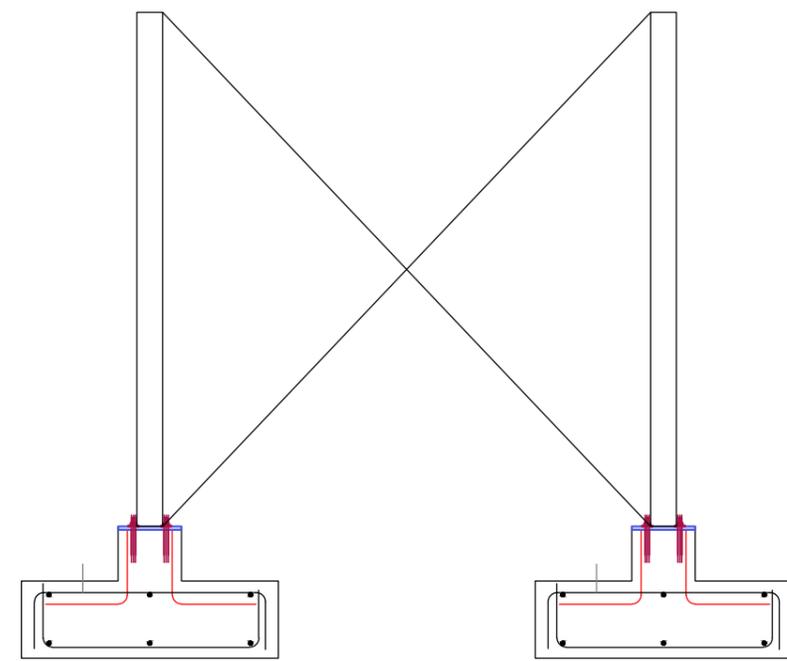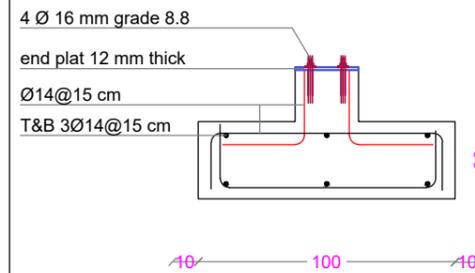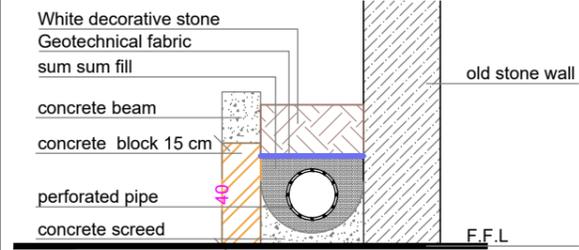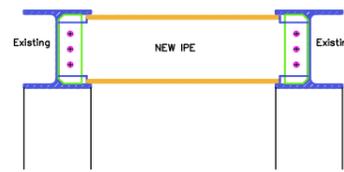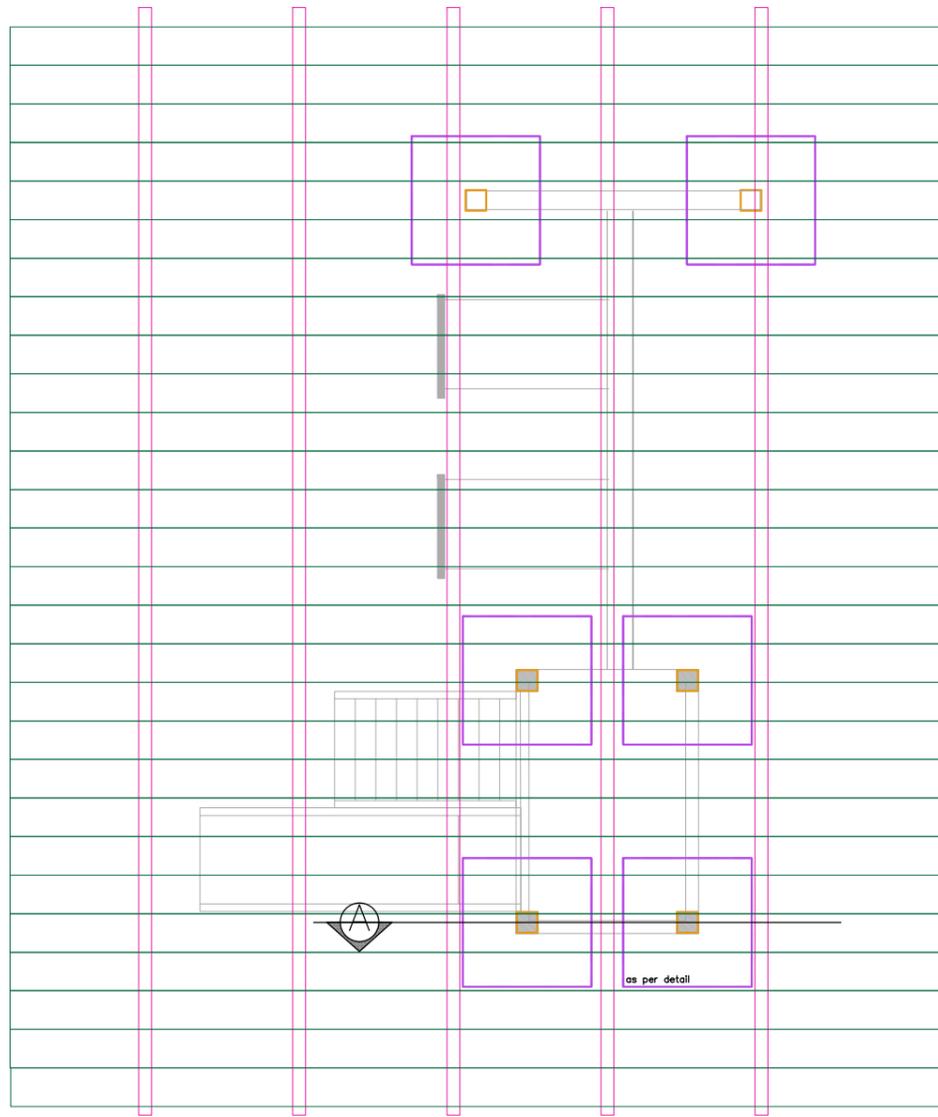

Notes
 (1) All Dimensions Are In M.
 (2) All Levels Are In Meter
 (3) Any Missing or Unclear Detail And All Fastening Systems For All Elements Shall be Approved by The Supervisor.

Legend:

	SECTION NUMBER		ROOM CODE
	REFERENCE SHEET NUMBER		ROOM ID
	REFERENCE DETAIL SHEET NUMBER		DOOR NUMBER
	FLOOR FINISH LEVEL (F.F.L.)		WINDOW NUMBER
	REINFORCEMENT CONCRETE LEVEL (R.C.L.)		REFERENCE DETAIL SHEET NUMBER
	LEVEL SIGN IN PLAN		DETAILED SECTION AT SHEET No. A09

	STEEL SHEETS		ENTRANCE
	RC CONCRETE FOR COLUMNS		SOUND INSULATION
	RC CONCRETE FOR WALLS		PORCELAIN TILES (PARQUET STYLE)
	CONCRETE		THERMAL INSULATION
	STONE WALL		
	HOLLOW BLOCKS		
	CEMENT TILE		
	PORCELAIN TILE		
	LOCAL MARBLE		
	Gypsum partition		

R.C.L.-REN. CONCRETE LEVEL
 F.F.L.-FINISH FLOOR LEVEL
 S.L. : SEA LEVEL

REVISIONS		
NO.	DRAWINGS	DATE
(1)		
(2)		
(3)		

Contracting Authority:
 Enabel - Belgian Development Agency

Funded By:

This Project is Funded by

EUROPEAN UNION

Belgium
partner in development

Project Title:
 Public services contract for "Participatory design and supervision of Public and Semi-Public spaces in East Jerusalem / Silwan neighborhood"

Reference No.: PZA170421T-10028


Designed by:

HOSH STUDIO
ARCHITECTURE & TOWN PLANNING


Jerusalem - Sheikh Jarrah - Tobler8
 email: mr.wasimhija@gmail.com

Tel: 02-9948344/ 052-8327076
 Fax: 02-9948344


Drawing Title	Structural Plan	Date: 28/3/2023
		Scale: 1:25
Designed by:	Eng. Ahmad Ayyad	Drawing No:
Checked by:	Eng. Ahmad Ayyad	S01
Approved by:		
Coordinate Manager:		

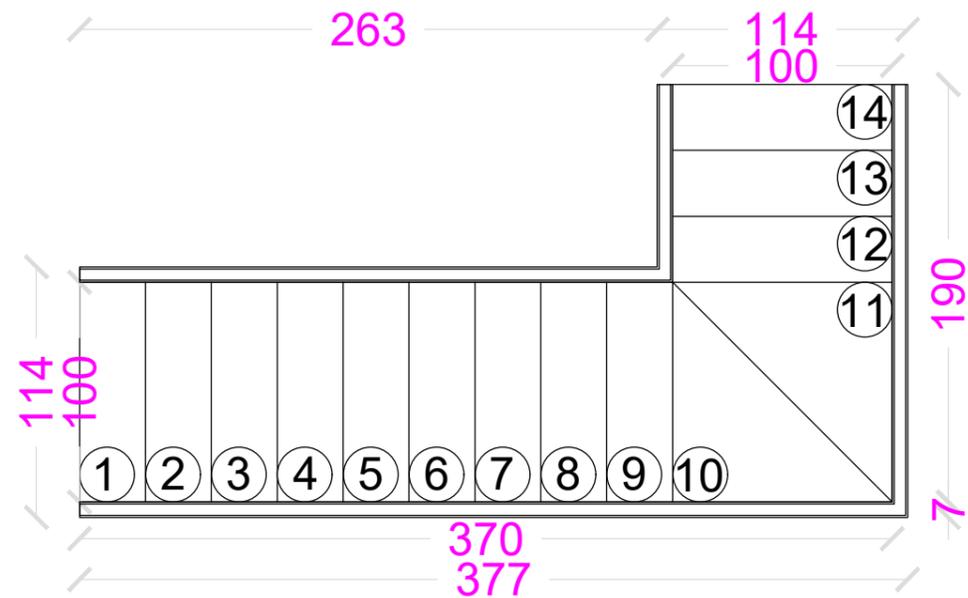

STEEL STAIR PLAN

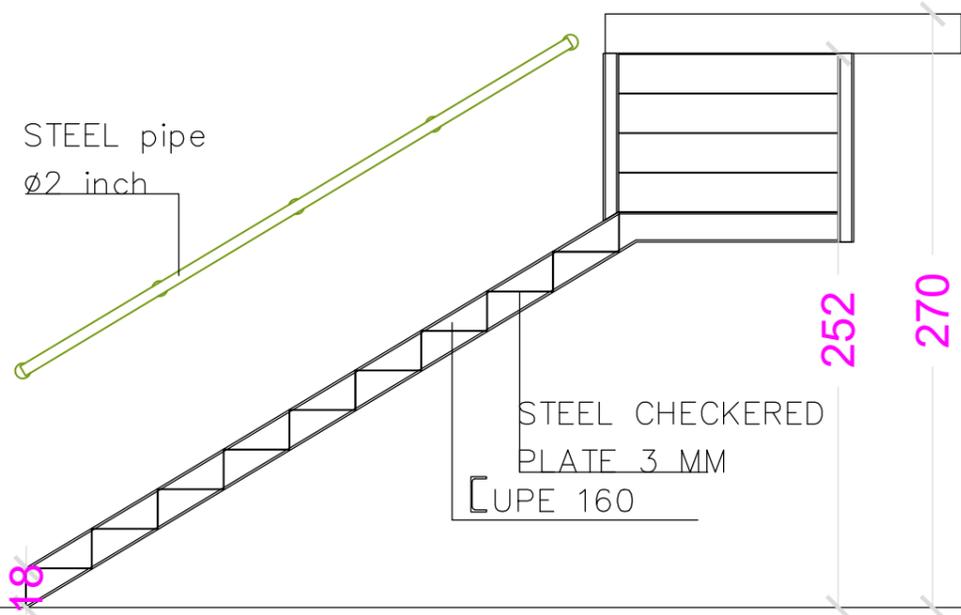

STEEL STAIR ELEVATION

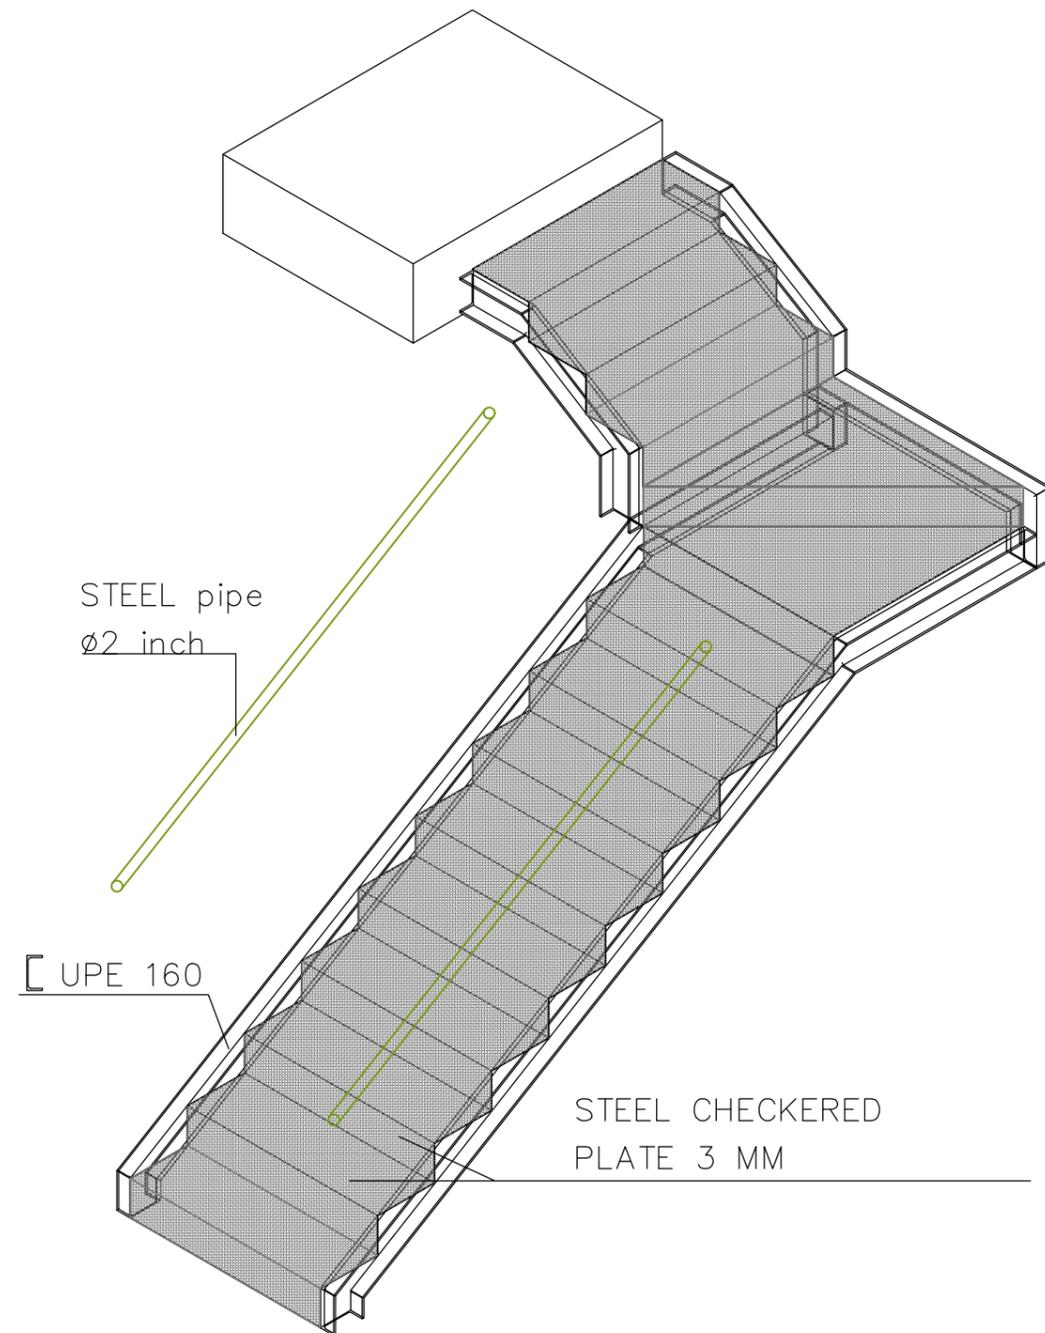

STEEL STAIR ISOMETRIC

Notes

- (1) All Dimensions Are In M.
- (2) All Levels Are In Meter
- (3) Any Missing or Unclear Detail And All Fastening Systems For All Elements Shall be Approved By The Supervisor.

Legend:

SECTION NUMBER	ROOM CODE	JUNCTION AREA
REFERENCE SHEET NUMBER	ROOM ID	
REFERENCE DETAIL SHEET NUMBER	DOOR NUMBER	WINDOW NUMBER
FLOOR FINISH LEVEL (F.F.L.)	REINFORCEMENT CONCRETE LEVEL (R.C.L.)	LEVEL SIGN IN PLAN
STEEL SHEETS	RC CONCRETE FOR COLUMNS	RC CONCRETE FOR WALLS
CONCRETE	STONE WALL	HOLLOW BLOCKS
CEMENT TILE	PORCELAIN TILE	LOCAL MARBLE
Gypsum partition	ENTRANCE	SOUND INSULATION
R.C.L. - REN. CONCRETE LEVEL	F.F.L. - FINISH FLOOR LEVEL	S.L. - SEA LEVEL
PORCELAIN TILES (PARQUET STYLE)	THERMAL INSULATION	

REVISIONS		
NO.	DRAWINGS	DATE
(1)		
(2)		
(3)		

Contracting Authority:
Enabel - Belgian Development Agency



Project Title:
Public services contract for "Participatory design and supervision of Public and Semi-Public spaces in East Jerusalem / Silwan neighborhood"
Reference No.: PZA170421T-10028


Designed by:

HOSH STUDIO
ARCHITECTURE & TOWN PLANNING



Jerusalem - Sheikh Jarrah - Tobler8
email: mr.wasimhija@gmail.com

Tel: 02-9948344 / 052-8327076
Fax: 02-9948344

Drawing Title	Steel Staircase Details	Date: 28/3/2023
Designed by:	Eng. Ahmad Ayyad	Drawing No:
Checked by:	Eng. Ahmad Ayyad	S02
Approved by:		
Coordinate Manager:		

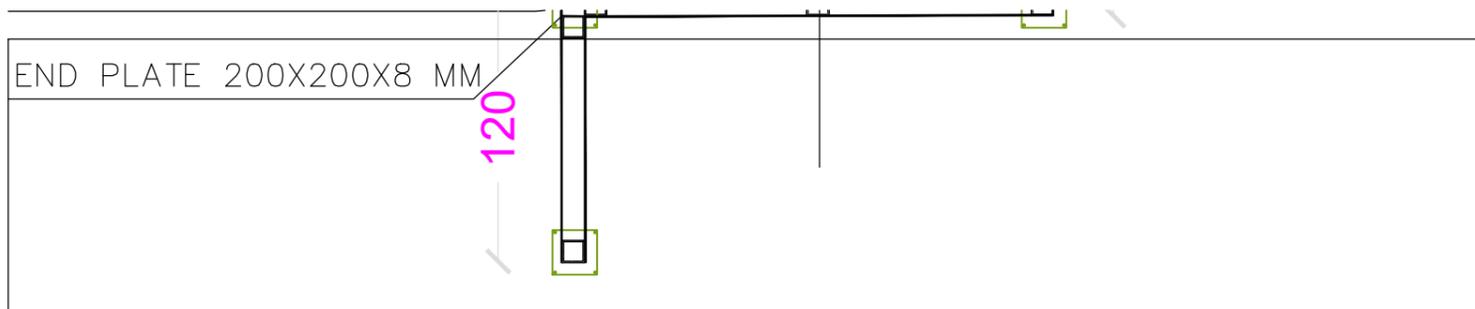

ROCK CLIMBING WALL STRUCTURAL PLAN

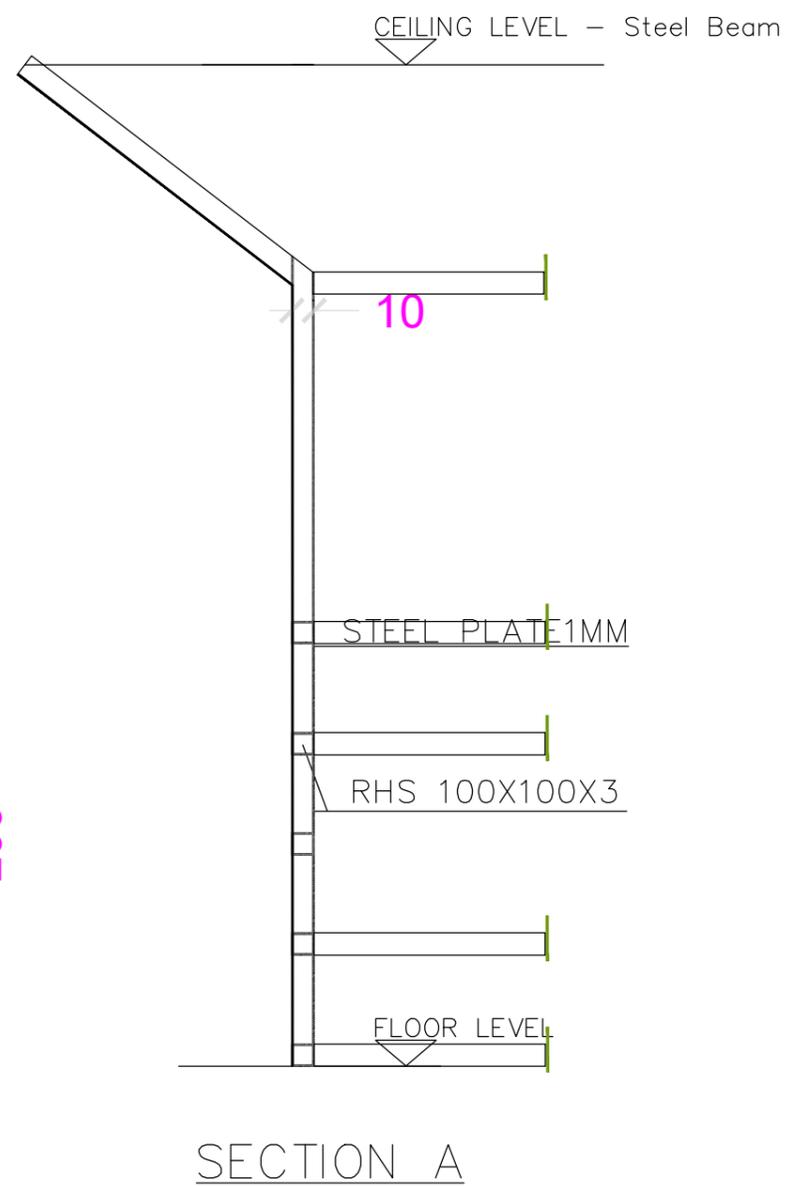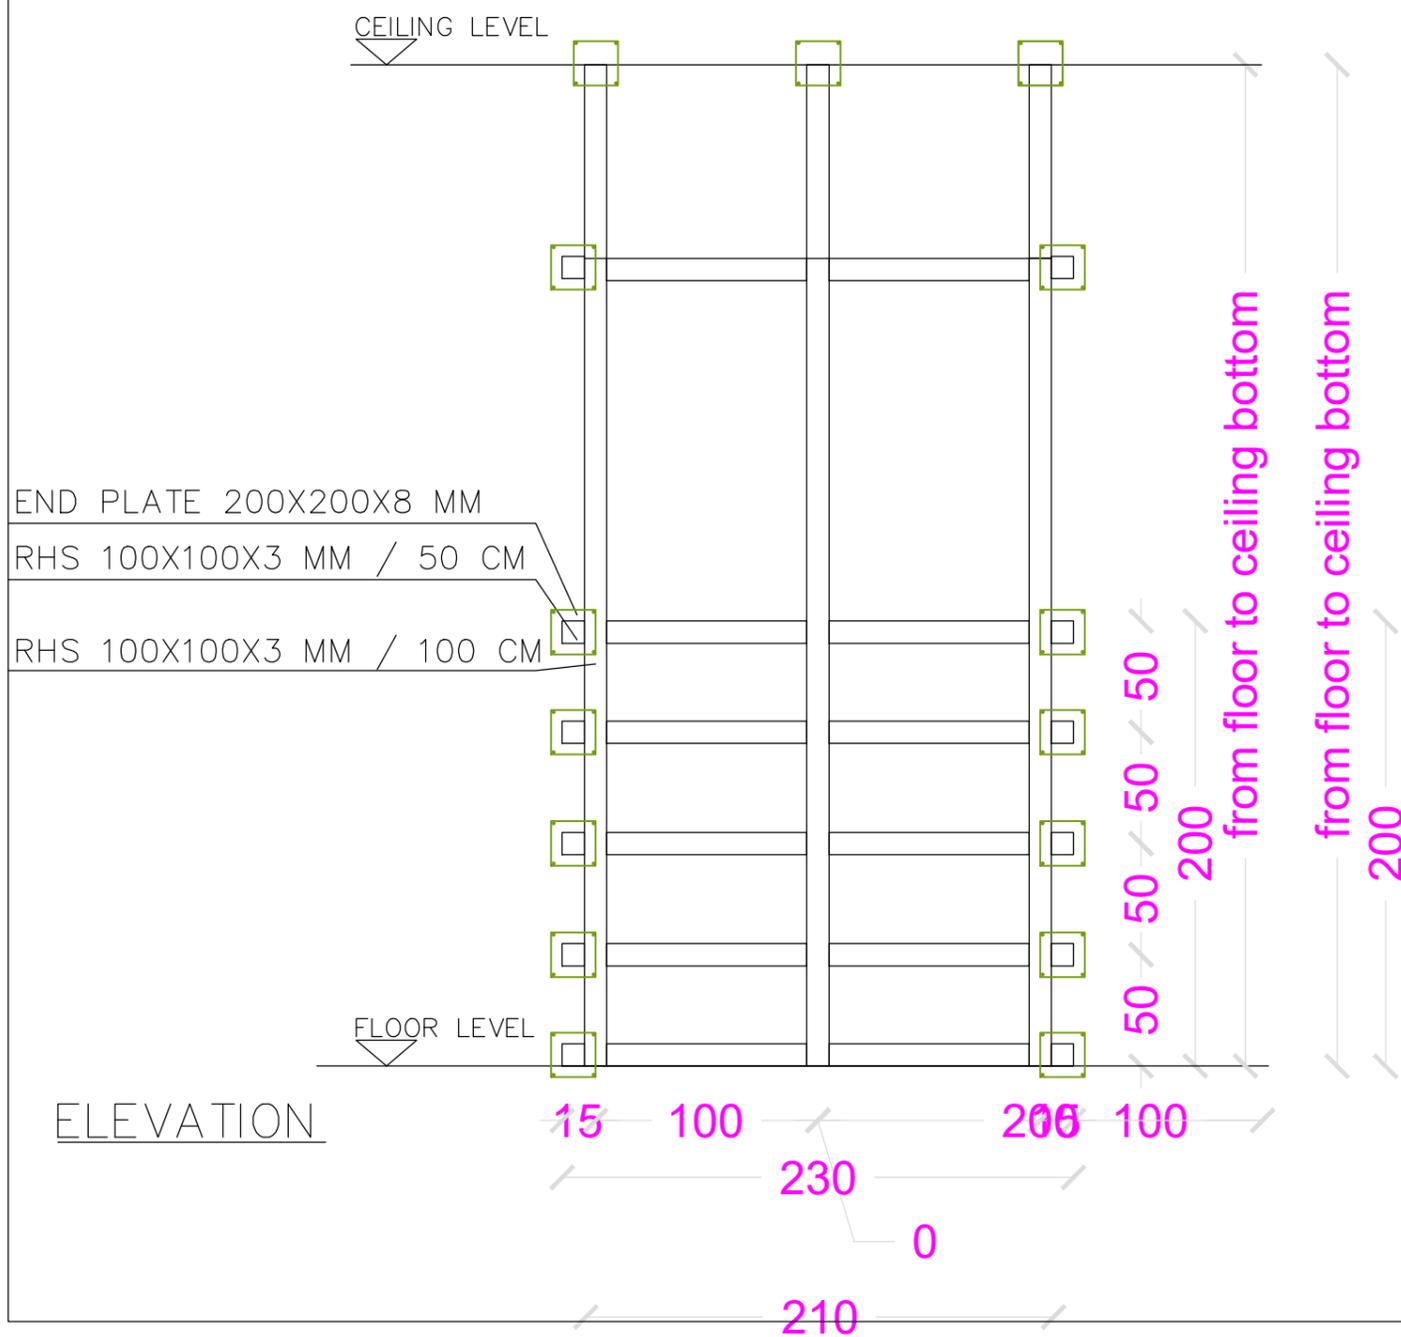

Notes

- (1) All Dimensions Are In M.
- (2) All Levels Are In Meter
- (3) Any Missing or Unclear Detail And All Fastening Systems For All Elements Shall be Approved by The Supervisor.

Legend:

SECTION NUMBER	ROOM CODE	FUNCTION AREA
REFERENCE SHEET NUMBER	ROOM ID	
FLOOR FINISH LEVEL (F.F.L.)	DOOR NUMBER	WINDOW NUMBER
REINFORCEMENT CONCRETE LEVEL (R.C.L.)	REFERENCE DETAIL SHEET NUMBER	DETAILED SECTION AT SHEET No. A09
LEVEL SIGN IN PLAN		

STEEL SHEETS	RC CONCRETE FOR COLUMNS	ENTRANCE
RC CONCRETE FOR WALLS	CONCRETE	SOUND INSULATION
STONE WALL	HOLLOW BLOCKS	PORCELAIN TILES (PARQUET STYLE)
CEMENT TILE	LOCAL MARBLE	THERMAL INSULATION
PORCELAIN TILE	Gypsum partition	

R.C.L.: REN. CONCRETE LEVEL
F.F.L.: FINISH FLOOR LEVEL
S.L.: SEA LEVEL

REVISIONS		
NO.	DRAWINGS	DATE
(1)		
(2)		
(3)		

Contracting Authority:
Enabel - Belgian Development Agency

Funded By:

This Project is Funded by

EUROPEAN UNION

Belgium
partner in development

Project Title:
Public services contract for "Participatory design and supervision of Public and Semi-Public spaces in East Jerusalem / Silwan neighborhood"

Reference No.: PZA170421T-10028

Designed by:


HOSH STUDIO
ARCHITECTURE & TOWN PLANNING

Jerusalem - Sheikh Jarrah - Tobler8
email: mr.wasimhija@gmail.com


Tel: 02-9948344 / 052-8327076
Fax: 02-9948344

Drawing Title	Climbing Board Detail	Date: 28/3/2023
Designed by:	Eng. Ahmad Ayyad	Scale: 1:20
Checked by:	Eng. Ahmad Ayyad	Drawing No: S03
Approved by:		
Coordinate Manager:		


4. Electrical Drawings

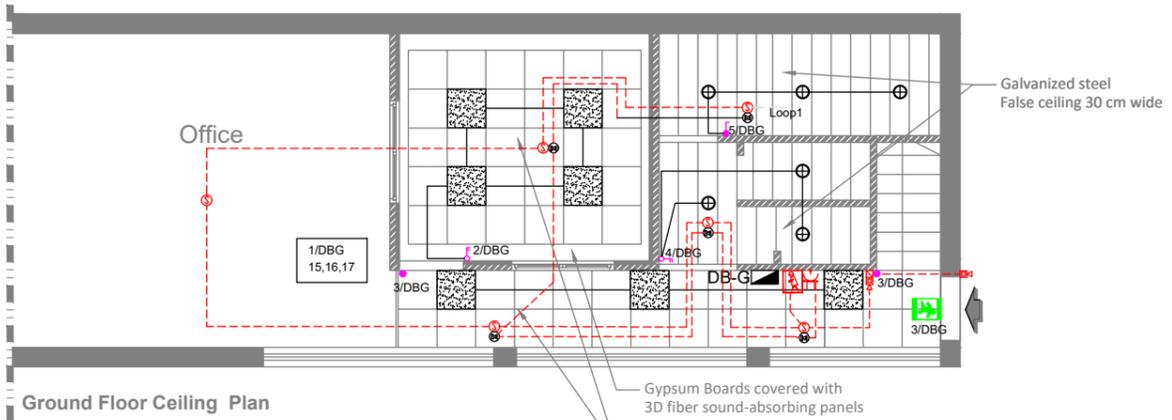


Ground Floor Ceiling Plan

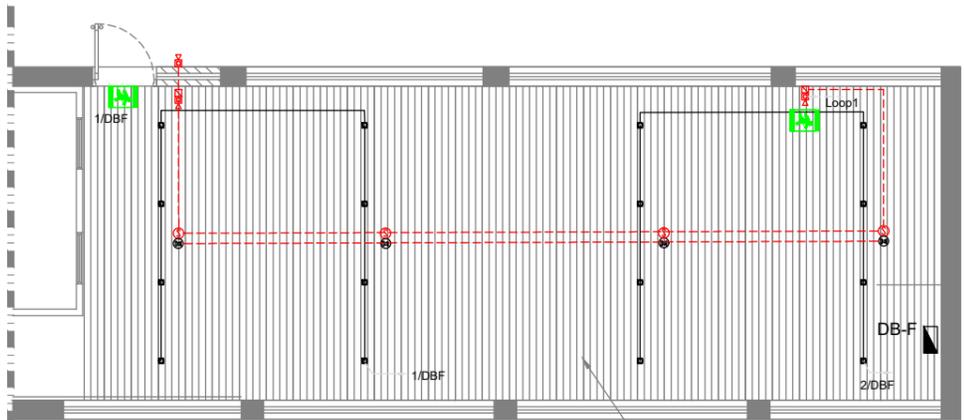

First Floor Ceiling Plan

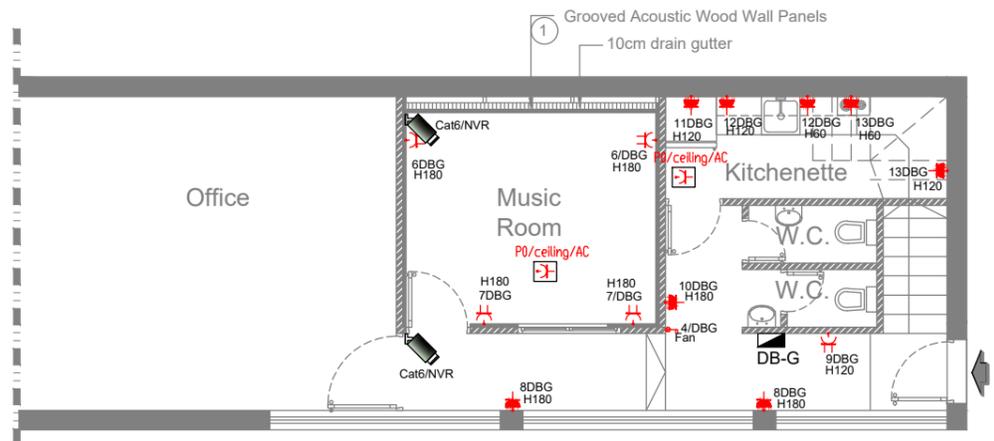

Proposed Ground Floor Furniture Plan

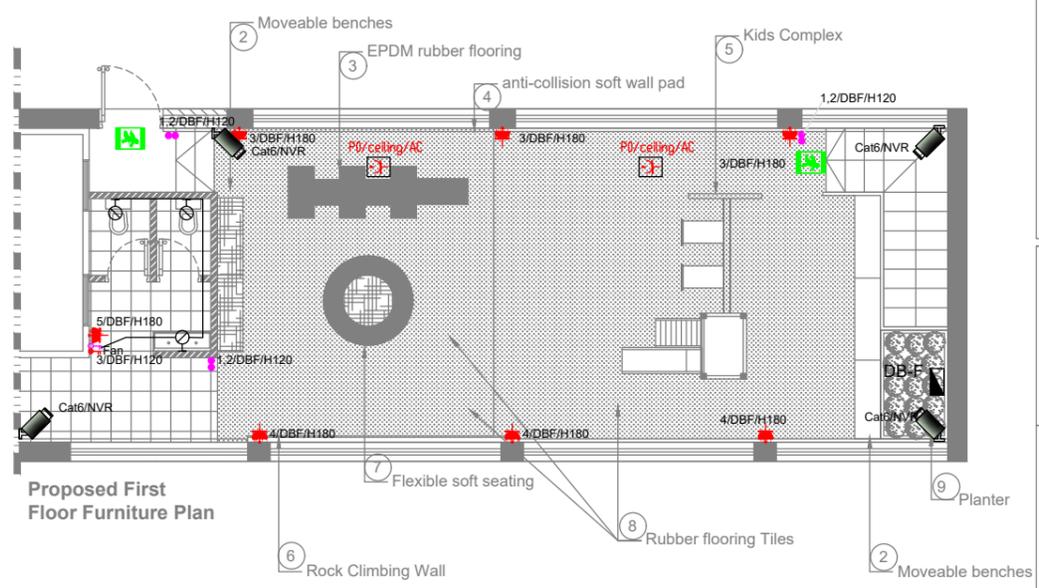

Proposed First Floor Furniture Plan

	10 watt down light 4000 k as per Nisko part light or approved equal
	60x60 cm LED panel as per false ceiling mount 40 watt, 4000 K Philips, Ledvance or approved equal.
	24 watt, 4000 K opal, LED downlight aluminum body complete with driver, IP54, ceiling recessed as Philips, Ledvance or approved equal
	12 watt wall mount light 4000 k as per Nisko Magnum light IP65 or approved equal
	3W LED Non-Maintained Emergency EXIT with self test function, min. 3 hours, electrozon or Eq. surface or recessed

Fire Alarm System	
	Fireman station
	Addressable Smoke DETECTOR
	Fire alarm manual pull station
	Fire alarm audiotone signal device
	Speaker

	16A 3 PIN SOCKET OUTLET / V.P.
	16A 3 PIN TVIN SOCKET OUTLET / V.P.
	SINGLE PHASE GP/ED ISOLATOR, Rate As Indicated
	SINGLE POLE ONE GANG SWITCH / V.P.
	SINGLE POLE THREE GANG SWITCH / V.P.
	PUSH BUTTON

Contracting Authority:
Enabel - Belgian Development Agency






Funded By:



Project Title:
Public services contract for "Participatory design and supervision of Public and Semi-Public spaces in East Jerusalem / Silwan neighborhood"
Reference No.: PZA170421T-10028

Designed by:


HOSH STUDIO
ARCHITECTURE & TOWN PLANNING
Jerusalem - Sheikh Jarrah- Tobler8
email: mr.wasimhija@gmail.com
Tel. 02-9948344/ 052-8327076
Fax: 02-9948344

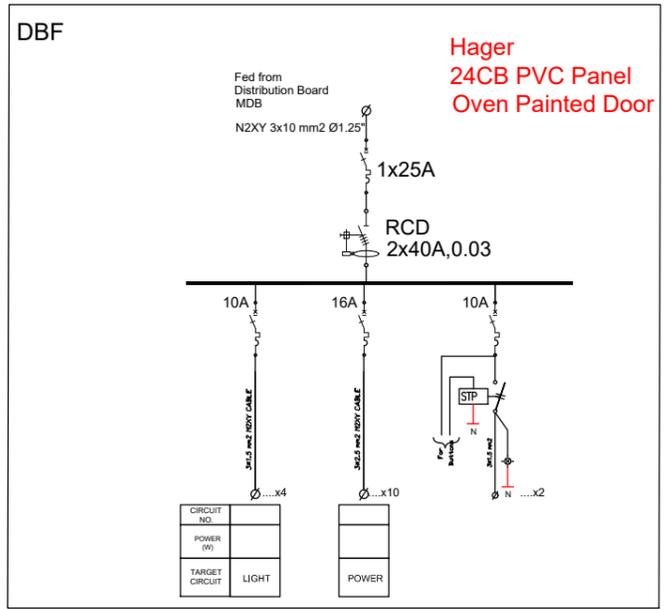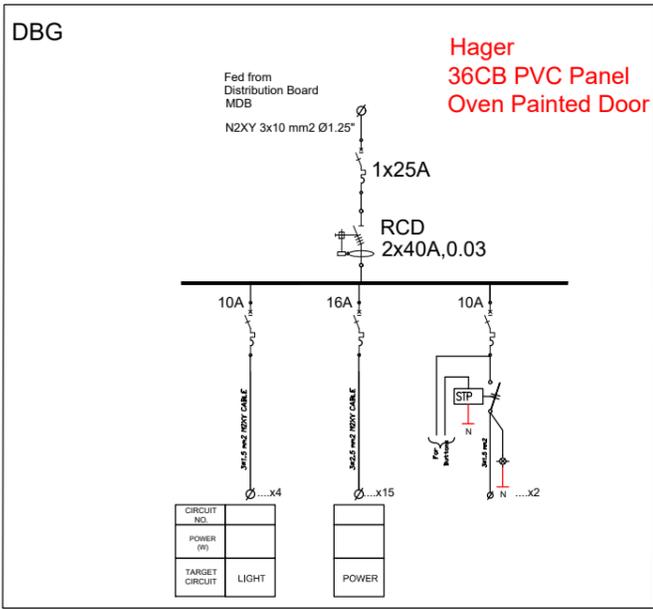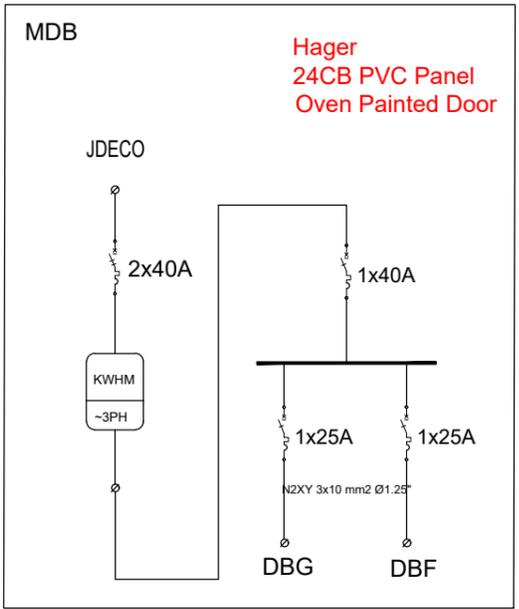

Drawing Title	Electrical Works	Date: 28/4/2023
Designed by:	M.Sharif	Scale: 1:100
Checked by:	Arch. Wasim Abu El-Hija	Drawing No: E01
Approved by:		
Coordinate Manager:		

3. Mechanical Drawings

M01	Mechanical Plans- Water Plans
M02	Mechanical Plans- Sewage Plans
M03	Mechanical Plans- HVAC Plan

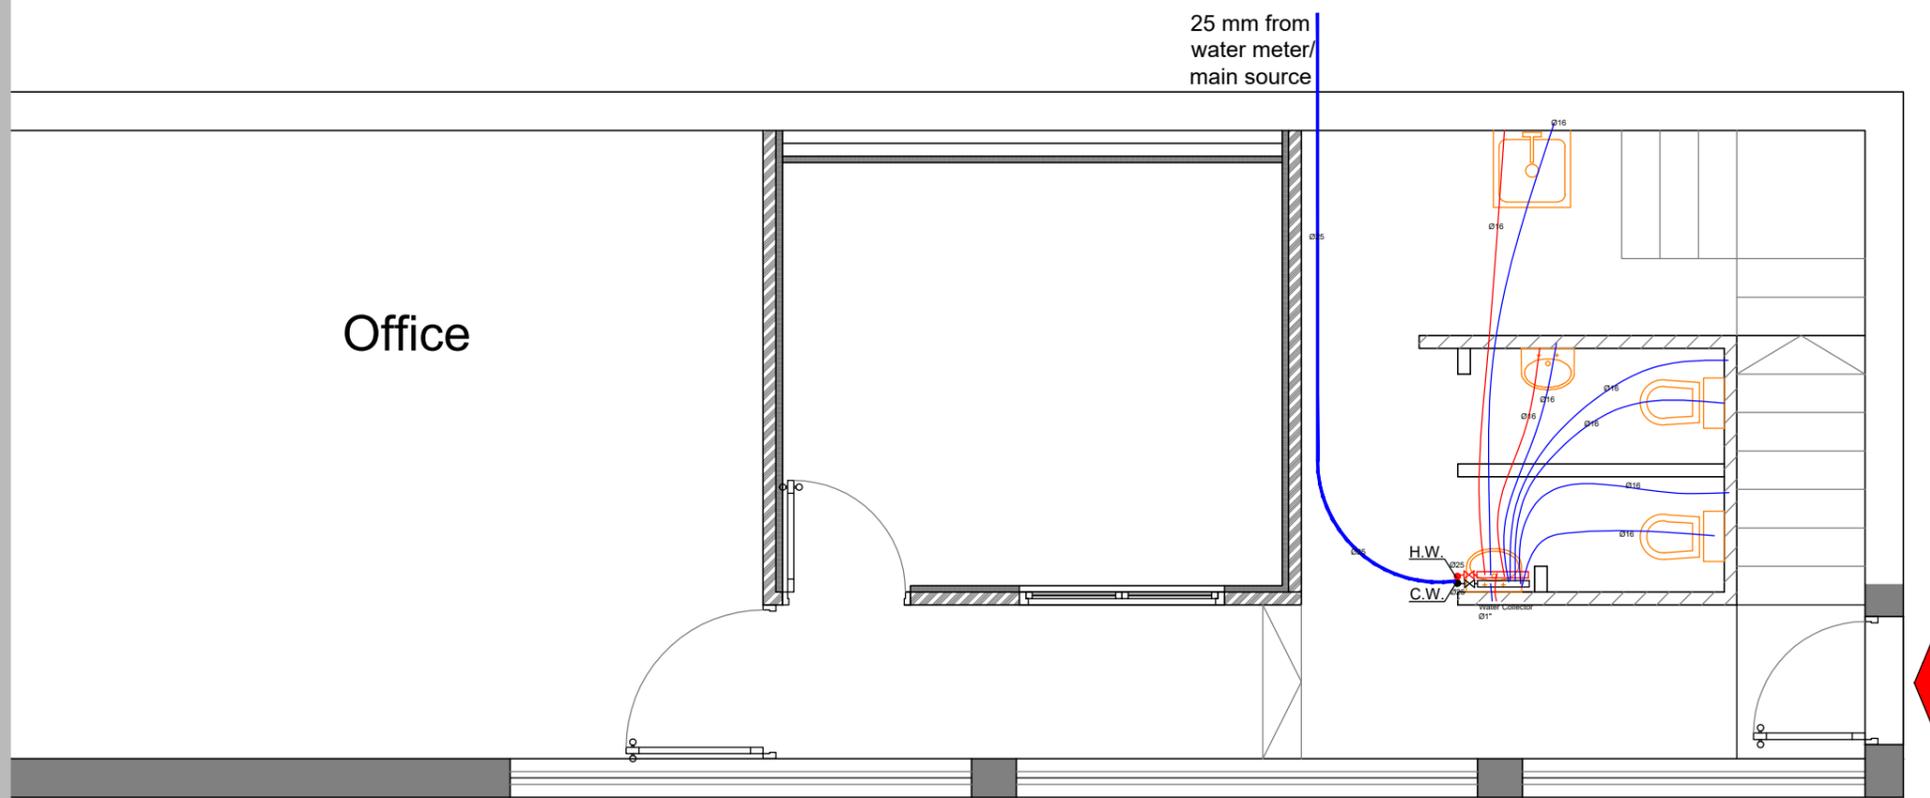

Water Ground Floor Plan



Water First Floor Plan

Notes

- (1) All Dimensions Are In M.
- (2) All Levels Are In Meter
- (3) Any Missing or Unclear Detail And All Fastening Systems For All Elements Shall be Approved by The Supervisor.

Legend:

SECTION NUMBER	ROOM FUNCTION AREA
REFERENCE SHEET NUMBER	ROOM ID
REFERENCE DETAIL SHEET NUMBER	DOOR NUMBER
FLOOR FINISH LEVEL (F.F.L.)	WINDOW NUMBER
REINFORCEMENT CONCRETE LEVEL (R.C.L.)	REFERENCE DETAIL SHEET NUMBER
LEVEL SIGN IN PLAN	DETAILED SECTION AT SHEET No. A09
STEEL SHEETS	ENTRANCE
RC CONCRETE FOR COLUMNS	SOUND INSULATION
RC CONCRETE FOR WALLS	PORCELAIN TILES (PARQUET STYLE)
CONCRETE	THERMAL INSULATION
STONE WALL	
HOLLOW BLOCKS	
CEMENT TILE	
PORCELAIN TILE	R.C.L.-REN. CONCRETE LEVEL
LOCAL MARBLE	F.F.L.-FINISH FLOOR LEVEL
Gypsum partition	S.L. - SEA LEVEL

REVISIONS		
NO.	DRAWINGS	DATE
(1)		
(2)		
(3)		

Contracting Authority:
Enabel - Belgian Development Agency





Funded By:
This Project is Funded by
 EUROPEAN UNION

Belgium
partner in development

Project Title:
Public services contract for "Participatory design and supervision of Public and Semi-Public spaces in East Jerusalem / Silwan neighborhood"
Reference No.: PZA170421T-10028

Designed by:
 HOSH STUDIO
ARCHITECTURE & TOWN PLANNING
Jerusalem - Sheikh Jarrah- Tobler8
email: mr.wasimhija@gmail.com
Tel. 02-9948344/ 052-8327076
Fax: 02-9948344

Drawing Title	Mechanical Plans	Date: 28/3/2023
Designed by:	Eng. Rami Siouri	Scale: 1:50
Checked by:	Arch. Wasim Abu El-Hija	Drawing No: M01
Approved by:		
Coordinate Manager:		

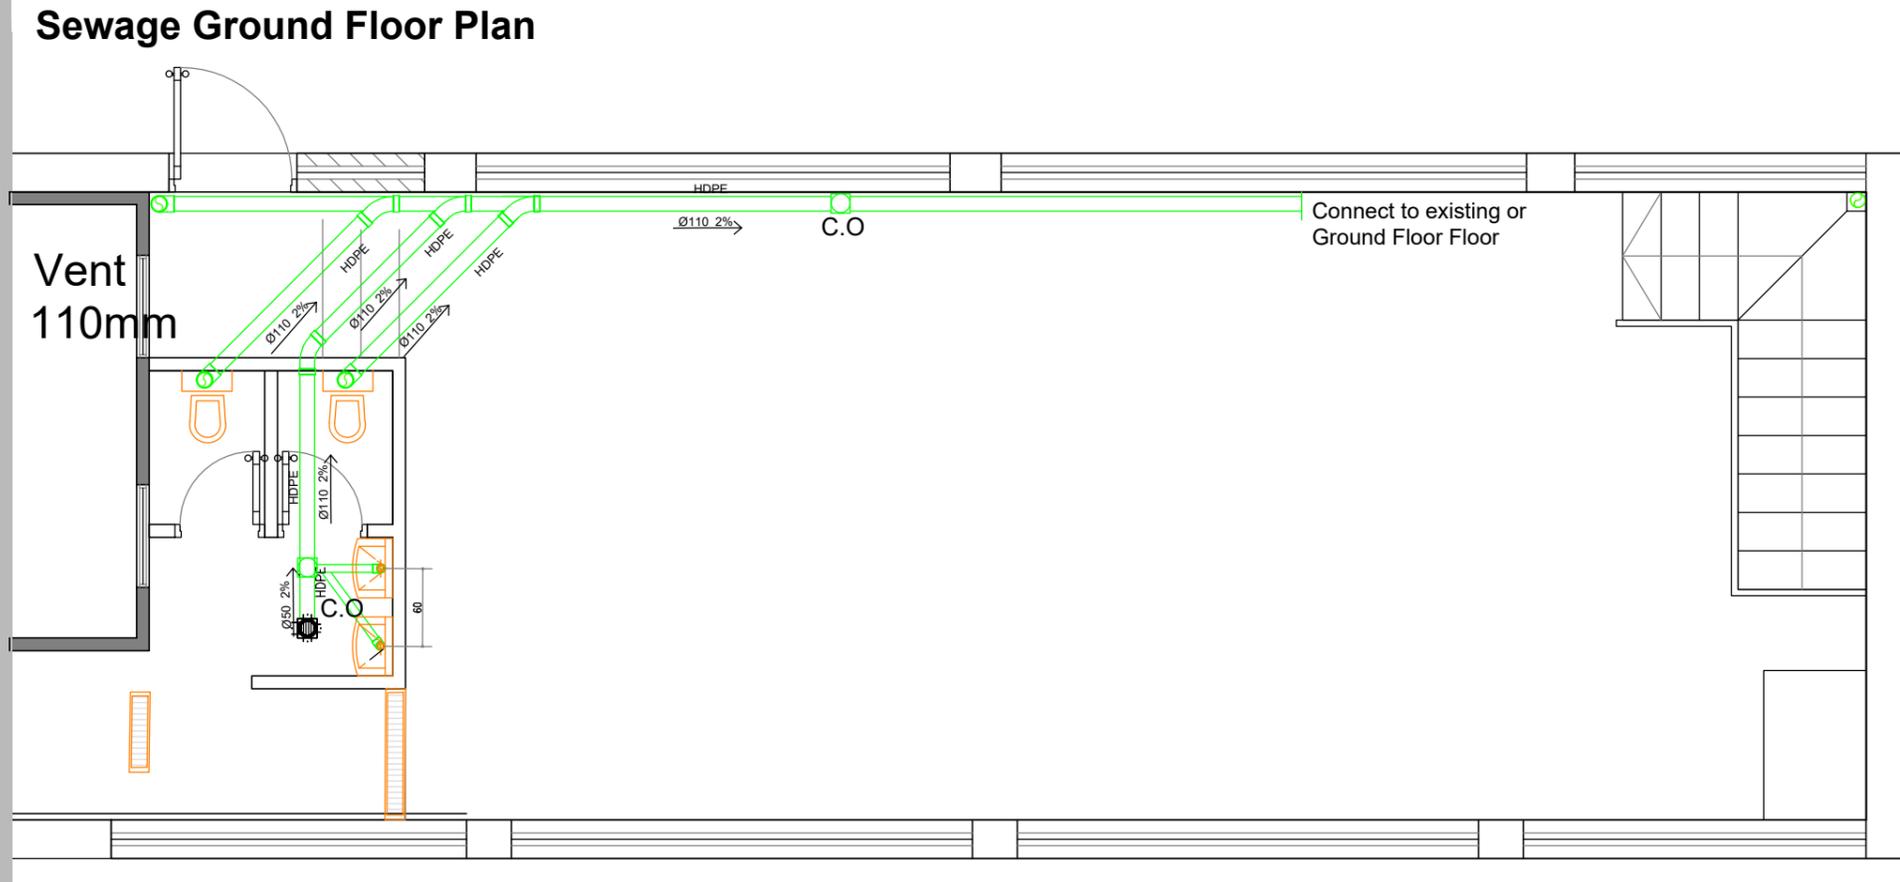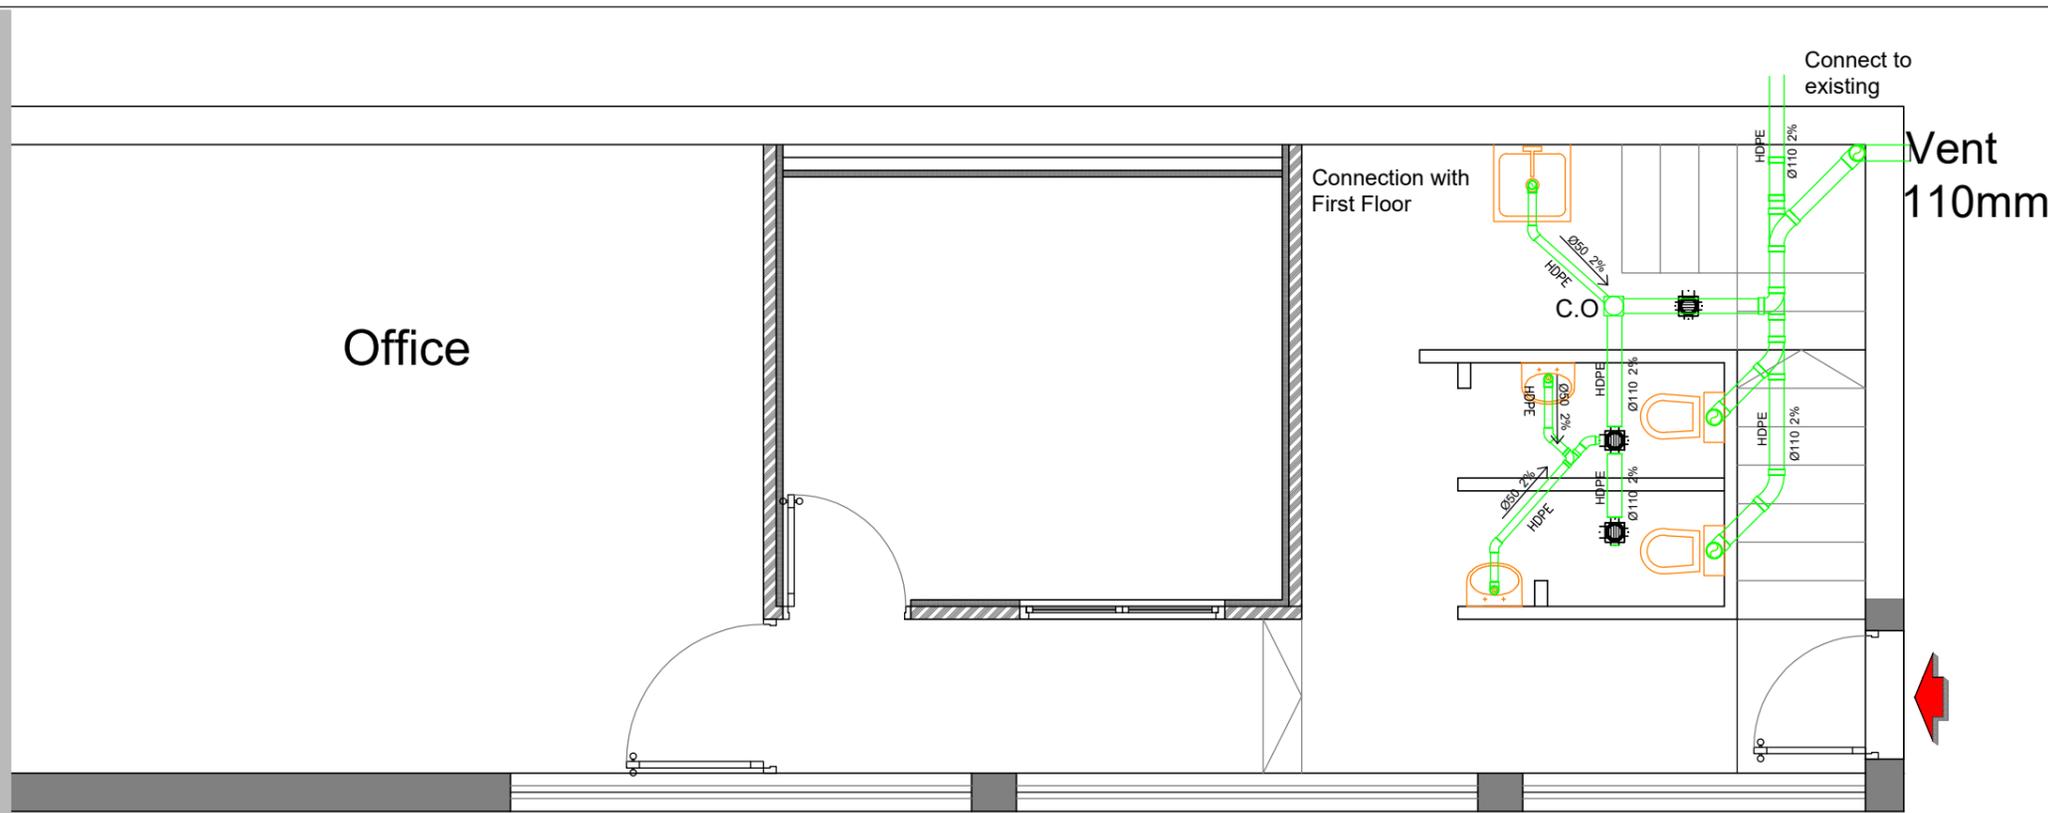

Notes

(1) All Dimensions Are In M.
 (2) All Levels Are In Meter
 (3) Any Missing or Unclear Detail And All Fastening Systems For All Elements Shall be Approved by The Supervisor.

Legend:

SECTION NUMBER	ROOM FUNCTION
REFERENCE SHEET NUMBER	ROOM AREA
REFERENCE DETAIL SHEET NUMBER	ROOM ID
FLOOR FINISH LEVEL (F.F.L.)	DOOR NUMBER
REINFORCEMENT CONCRETE LEVEL (R.C.L.)	WINDOW NUMBER
LEVEL SIGN IN PLAN	DETAILED SECTION AT SHEET NO. A09

STEEL SHEETS	ENTRANCE
RC CONCRETE FOR COLUMNS	SOUND INSULATION
RC CONCRETE FOR WALLS	PORCELAIN TILES (PARQUET STYLE)
CONCRETE	THERMAL INSULATION
STONE WALL	
HOLLOW BLOCKS	
CEMENT TILE	
PORCELAIN TILE	
LOCAL MARBLE	
Gypsum partition	

R.C.L.-REN. CONCRETE LEVEL
 F.F.L.-FINISH FLOOR LEVEL
 S.L. - SEA LEVEL

REVISIONS		
NO.	DRAWINGS	DATE
(1)		
(2)		
(3)		

Contracting Authority:
 Enabel - Belgian Development Agency

Funded By:

EUROPEAN UNION

Project Title:
 Public services contract for "Participatory design and supervision of Public and Semi-Public spaces in East Jerusalem / Silwan neighborhood"

Reference No.: PZA170421T-10028


Designed by:

HOSH STUDIO
 ARCHITECTURE & TOWN PLANNING

Jerusalem - Sheikh Jarrah- Tobler8
 email: mr.wasimhija@gmail.com

Tel. 02-9948344/ 052-8327076
 Fax: 02-9948344

Drawing Title	Mechanical Plans	Date: 28/3/2023
		Scale: 1:50
Designed by:	Eng. Rami Siouri	Drawing No: M02
Checked by:	Arch. Wasim Abu El-Hija	
Approved by:		
Coordinate Manager:		

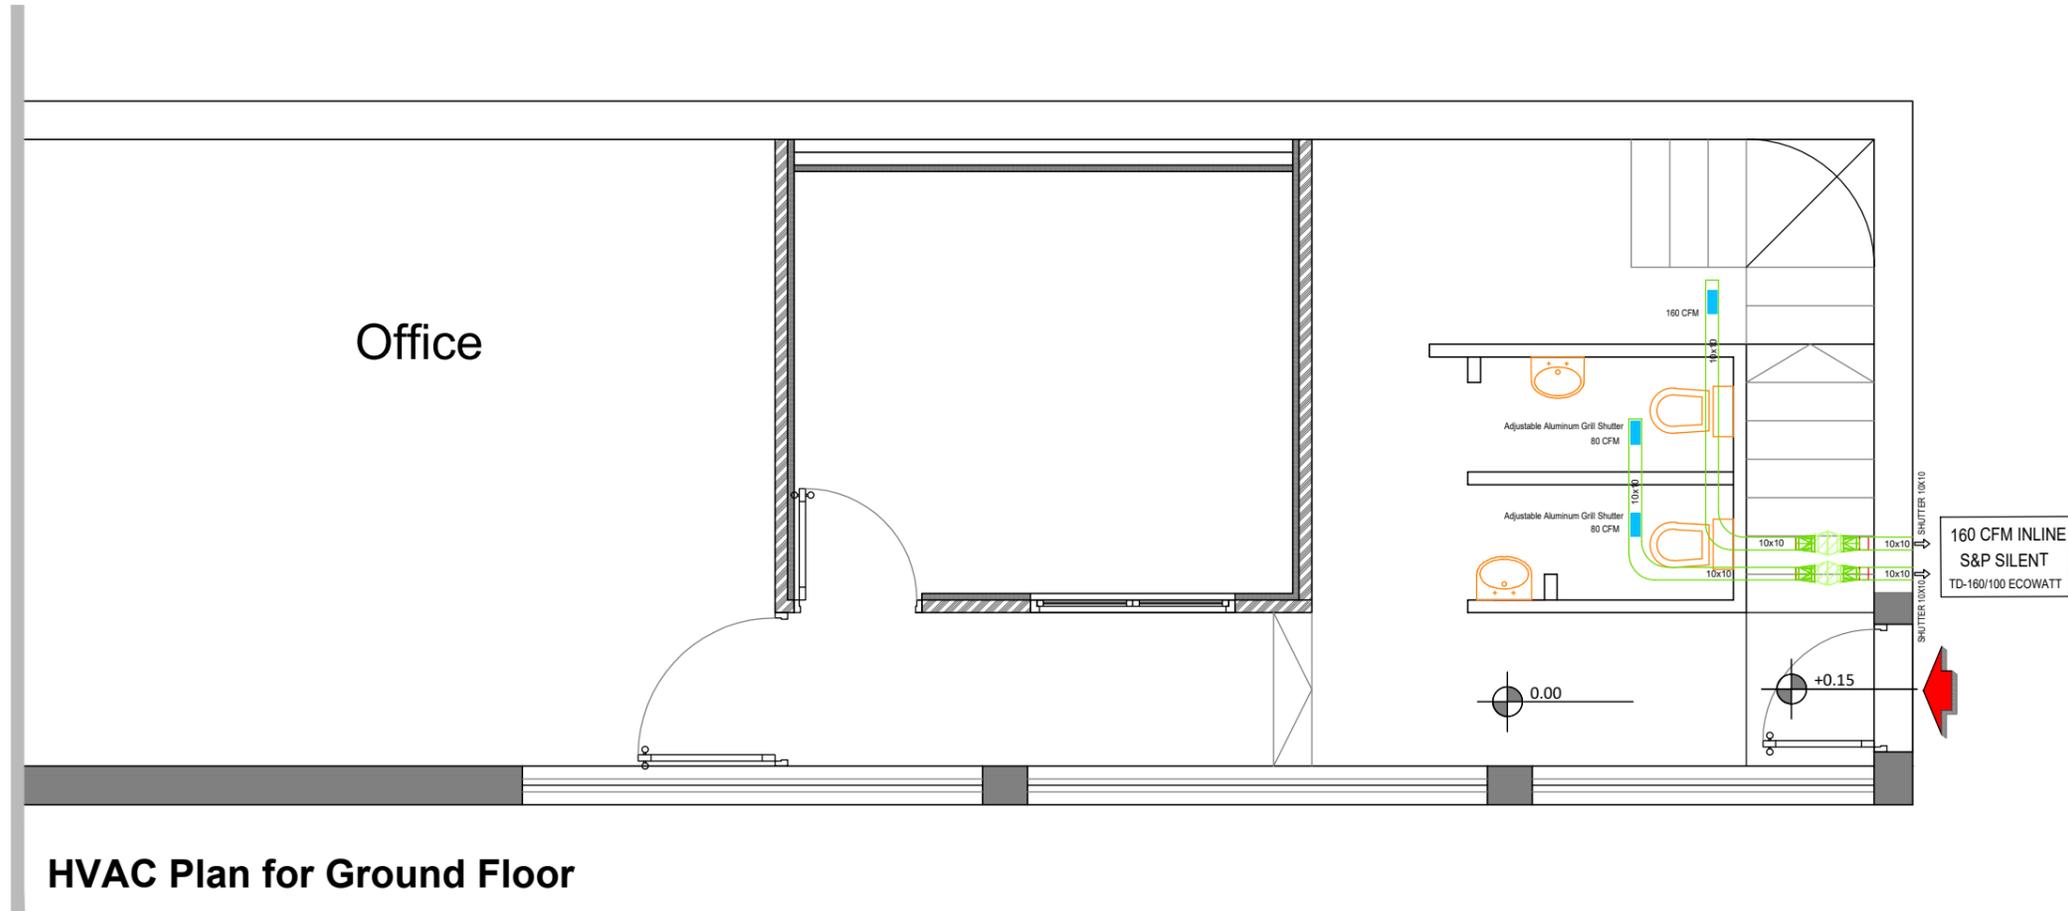

HVAC Plan for Ground Floor

Notes

- (1) All Dimensions Are In M.
- (2) All Levels Are In Meter
- (3) Any Missing or Unclear Detail And All Fastening Systems For All Elements Shall be Approved by The Supervisor.

Legend:

SECTION NUMBER	ROOM CODE	FUNCTION AREA
REFERENCE SHEET NUMBER	ROOM ID	
REFERENCE DETAIL SHEET NUMBER	DOOR NUMBER	WINDOW NUMBER
FLOOR FINISH LEVEL (F.F.L.)	REFERENCE DETAIL SHEET NUMBER	REFERENCE DETAIL SHEET NUMBER
REINFORCEMENT CONCRETE LEVEL (R.C.L.)	DETAILED SECTION AT SHEET No. ADD	
LEVEL SIGN IN PLAN	ENTRANCE	SOUND INSULATION
STEEL SHEETS	PORCELAIN TILES (PARQUET STYLE)	THERMAL INSULATION
RC CONCRETE FOR COLUMNS	LOCAL MARBLE	R.C.L. - REN. CONCRETE LEVEL
RC CONCRETE FOR WALLS	F.F.L. - FINISH FLOOR LEVEL	S.L. : SEA LEVEL
CONCRETE		
STONE WALL		
HOLLOW BLOCKS		
CEMENT TILE		
PORCELAIN TILE		
Gypsum partition		

REVISIONS		
NO.	DRAWINGS	DATE
(1)		
(2)		
(3)		

Contracting Authority:
Enabel - Belgian Development Agency

Funded By:

EUROPEAN UNION

Project Title:
Public services contract for "Participatory design and supervision of Public and Semi-Public spaces in East Jerusalem / Silwan neighborhood"

Reference No.: PZA170421T-10028

Designed by:

HOSH STUDIO
ARCHITECTURE & TOWN PLANNING

Jerusalem - Sheikh Jarrah- Tobler6
email: mr.wasimhija@gmail.com

Tel. 02-9948344/ 052-8327076
Fax: 02-9948344

Drawing Title	HVAC Plan	Date: 28/3/2023
Designed by:	Eng. Rami Slouri	Scale: 1:50
Checked by:	Arch. Wasim Abu El-Hija	Drawing No: M03
Approved by:		
Coordinate Manager:		