Enabel - Belgian Development Agency



Public services contract for

"THE CREATION OF AL-SAFA KINDERGARTEN AND THE REHABILITATION OF AL-SAFA BASIC SCHOOL IN BEIT SAFAFA"

Al-Safa school kindergarten


Reference No.: PZA170421T-10055

Funded By





Designed by

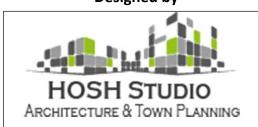

Jerusalem - Sheikh Jarrah- Tobler8


"THE CREATION OF AL-SAFA KINDERGARTEN AND THE REHABILITATION OF AL-SAFA BASIC SCHOOL IN BEIT SAFAFA"


Al-Safa school kindergarten

Reference No.: PZA170421T-10055

Architectural Drawings



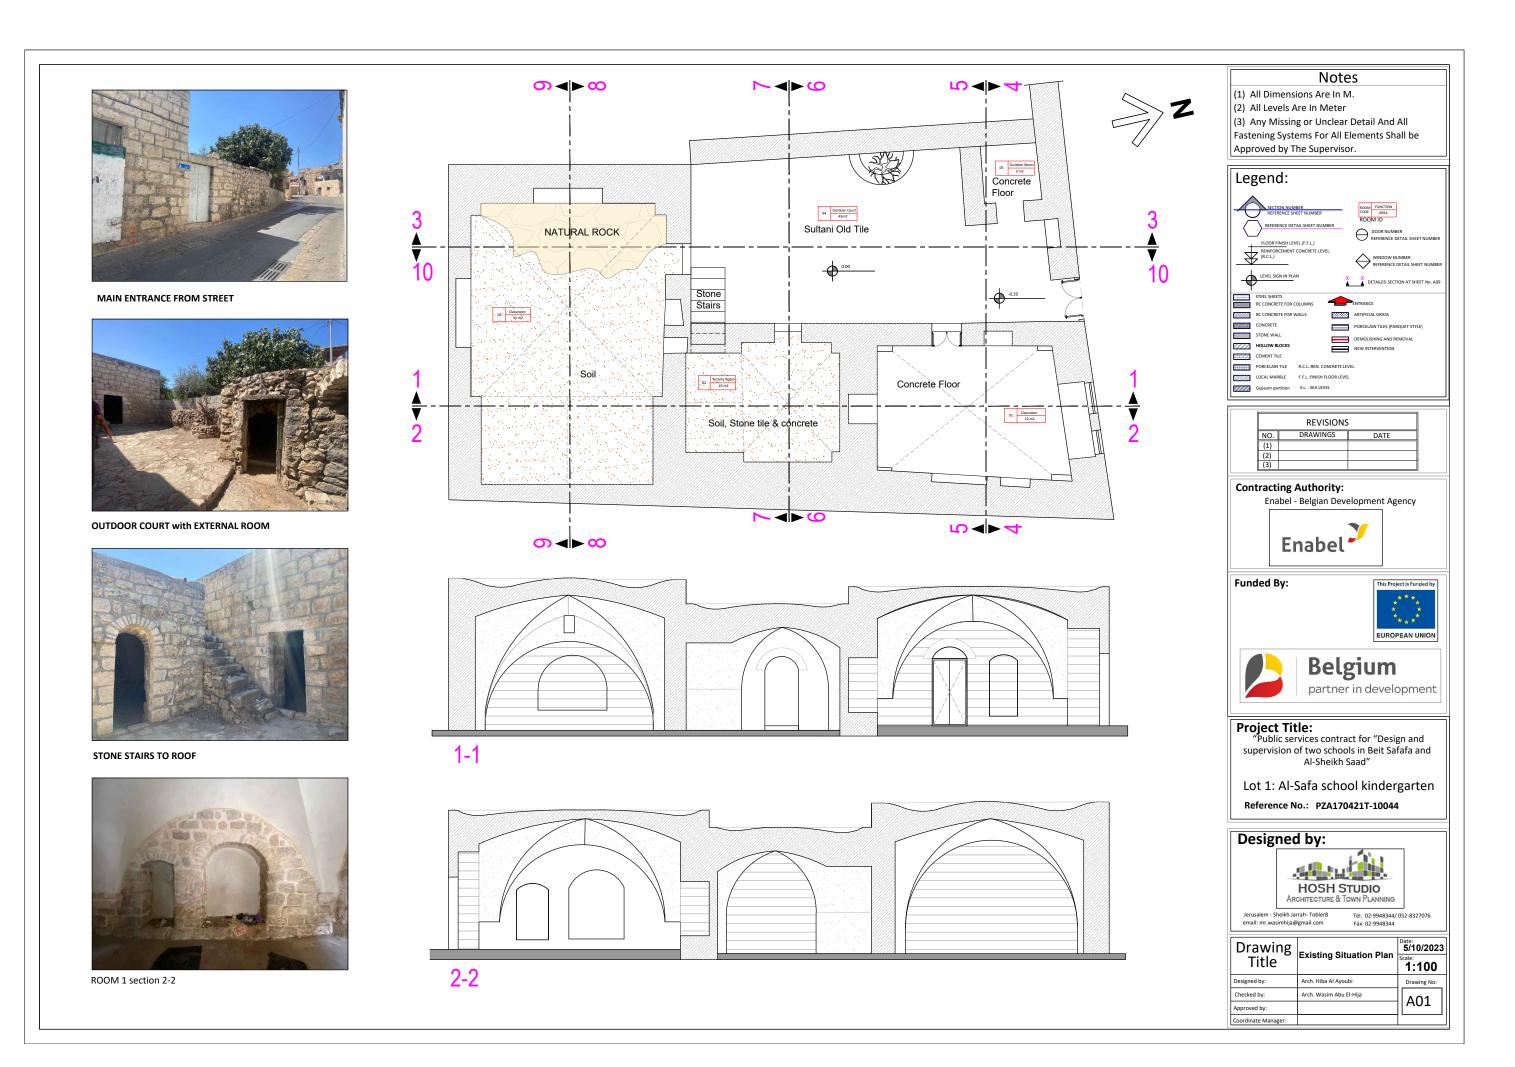

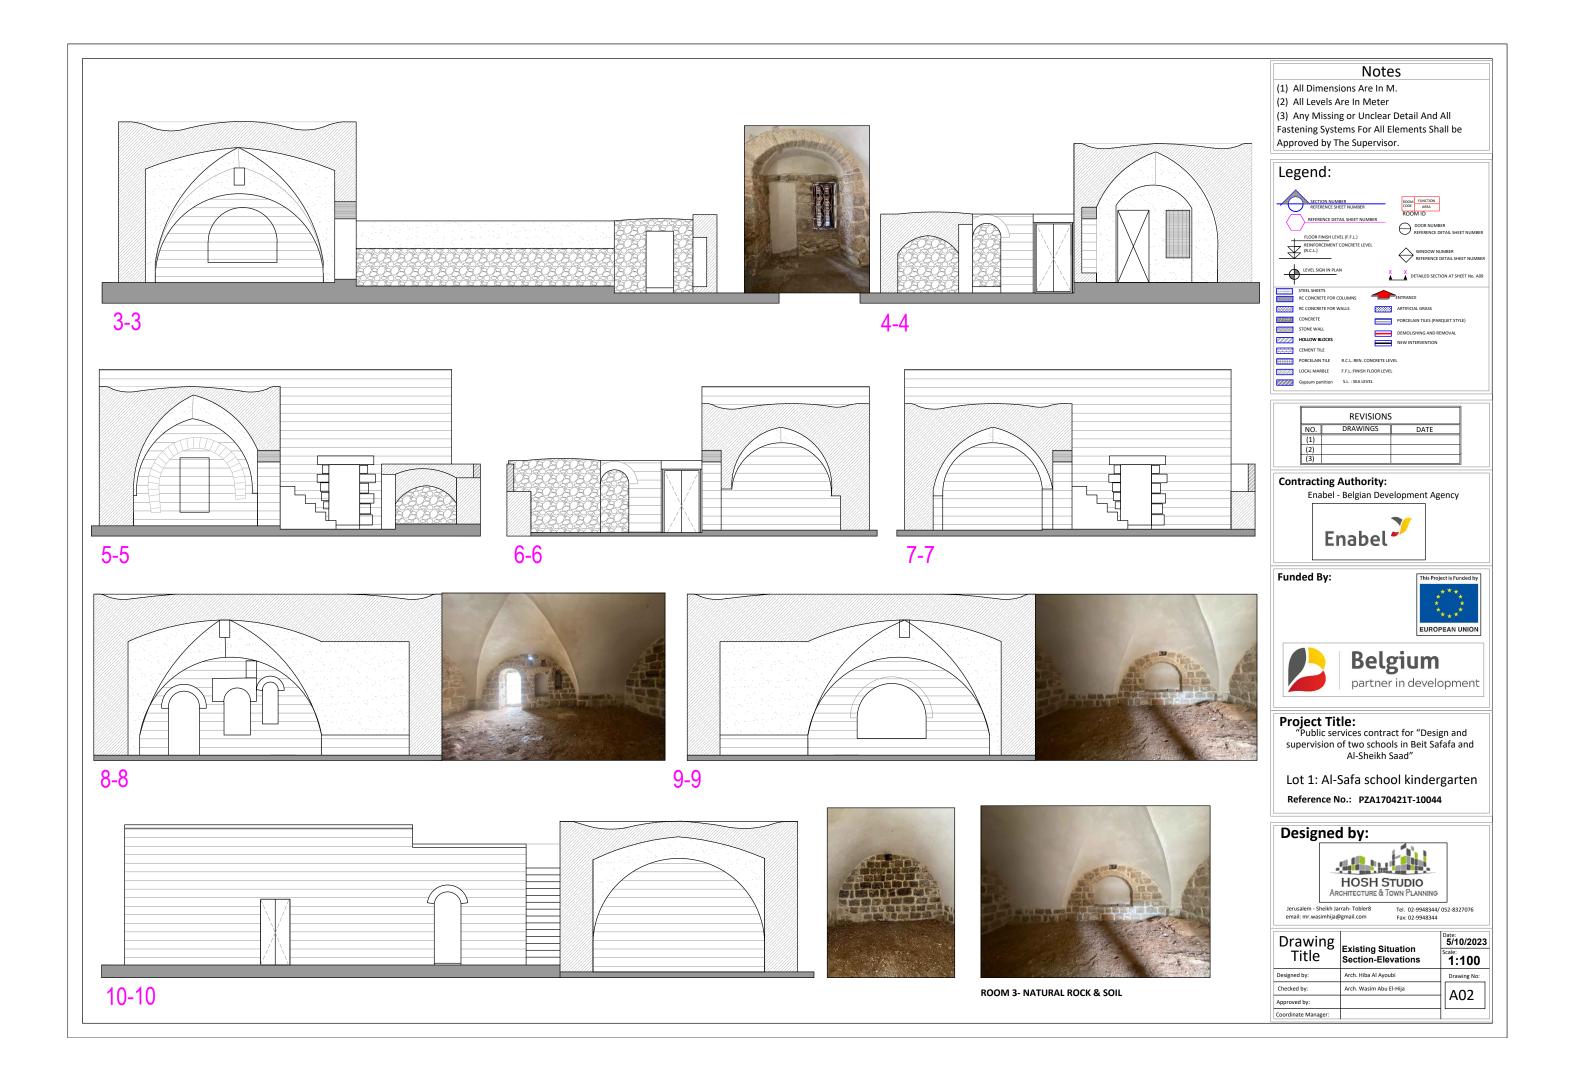



Cleaning Stone in the elevations with fixing pointing



Demolishing Stone Wall, Brick, Planter, Sultani Tiles, and Outdoor room with numbering the stone of the room to rebuild it again



Demolishing Natural Rock



Demolishing first 5 stone steps



Cleaning Stone in the elevations with fixing pointing



Dismantling Sultani Old Tile, dift & soil

Demolishing the stone wall to

open a window

Demolishing stone wall & Room 5

Removing Soil, stone & concret

up to 30 cm

CHISELING & EXCAVATION

Demolishing the

open a window


Removing Soil up to 30 cm

OF NATURAL ROCK

Dismantling the metal door and Opening the wall for a window inside the arch Dismantling the concrete floor



Dismantling the window, door and entrance's gate

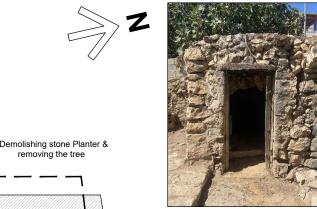

Dismantling

Concrete

Floor

Dismantling Concrete Floor

Demolishing Outdoor room with numbering the stone of the room to rebuild it again & dismantling the concrete floor

Dismantle the metal gate

the door

Dismantle the closing material of

Dismantle the metal window, shutter, & metal protection

Enabel - Belgian Development Agency



Funded By:





Project Title:

"Public services contract for "Design and supervision of two schools in Beit Safafa and Al-Sheikh Saad"

Lot 1: Al-Safa school kindergarten Reference No.: PZA170421T-10044

Designed by:



Jerusalem - Sheikh Jarrah- Tobler8 email: mr.wasimhija@gmail.com

Tel. 02-9948344/ 052-8327076


Drawing Title	Demolition Plan	5/10/2023 Scale: 1:100
Designed by:	Arch. Hiba Al Ayoubi	Drawing No:
Checked by:	Arch. Wasim Abu El-Hija	A03
Approved by:		AUS
Coordinate Manager:		



(1) All Dimensions Are In M. (2) All Levels Are In Meter

 (3) Any Missing or Unclear Detail And All Fastening Systems For All Elements Shall be Approved by The Supervisor.



 

























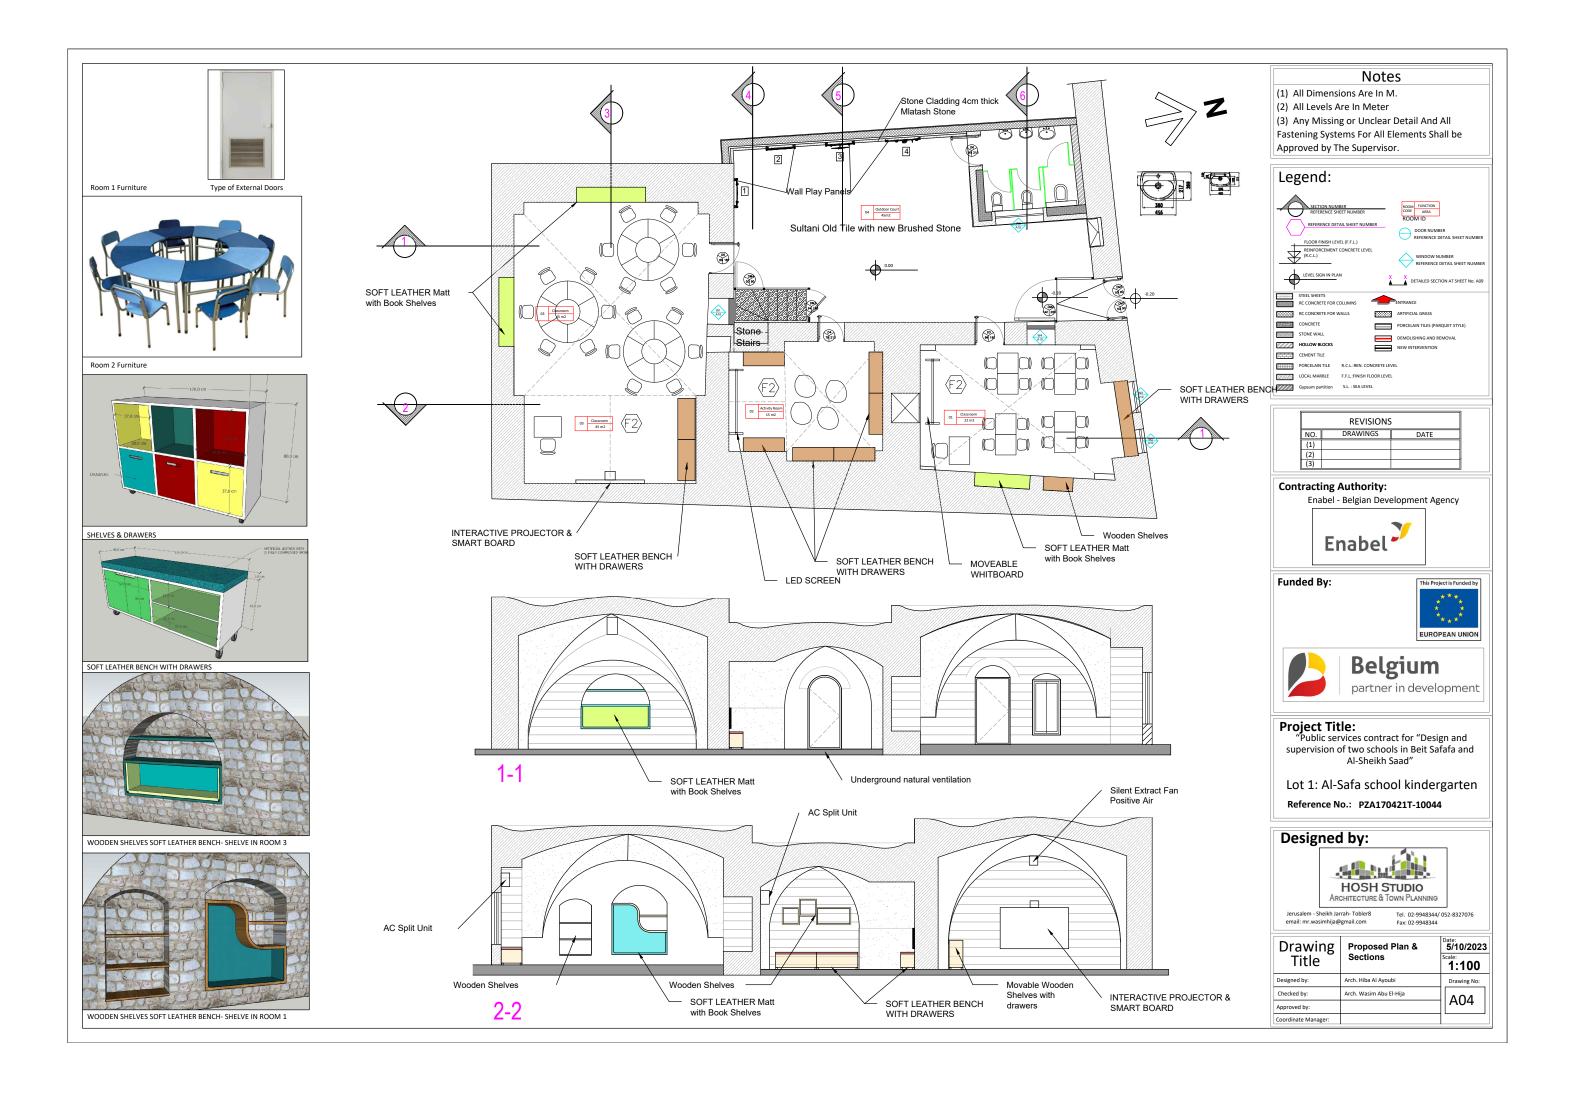


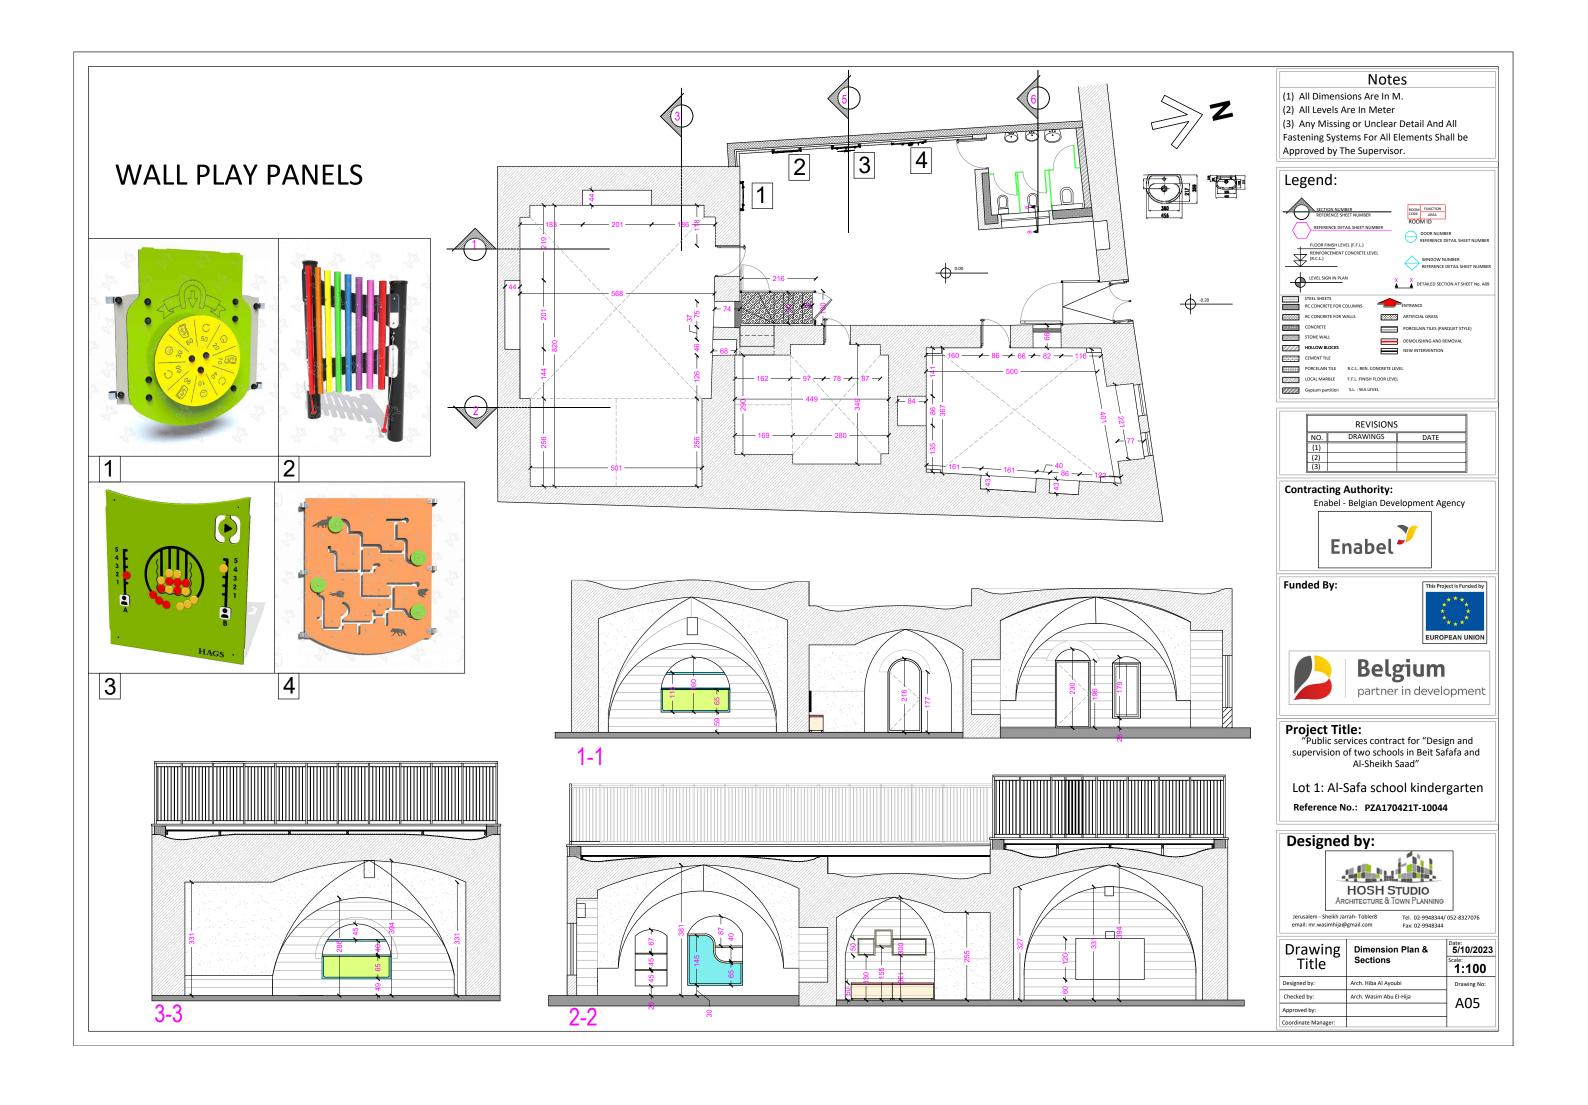

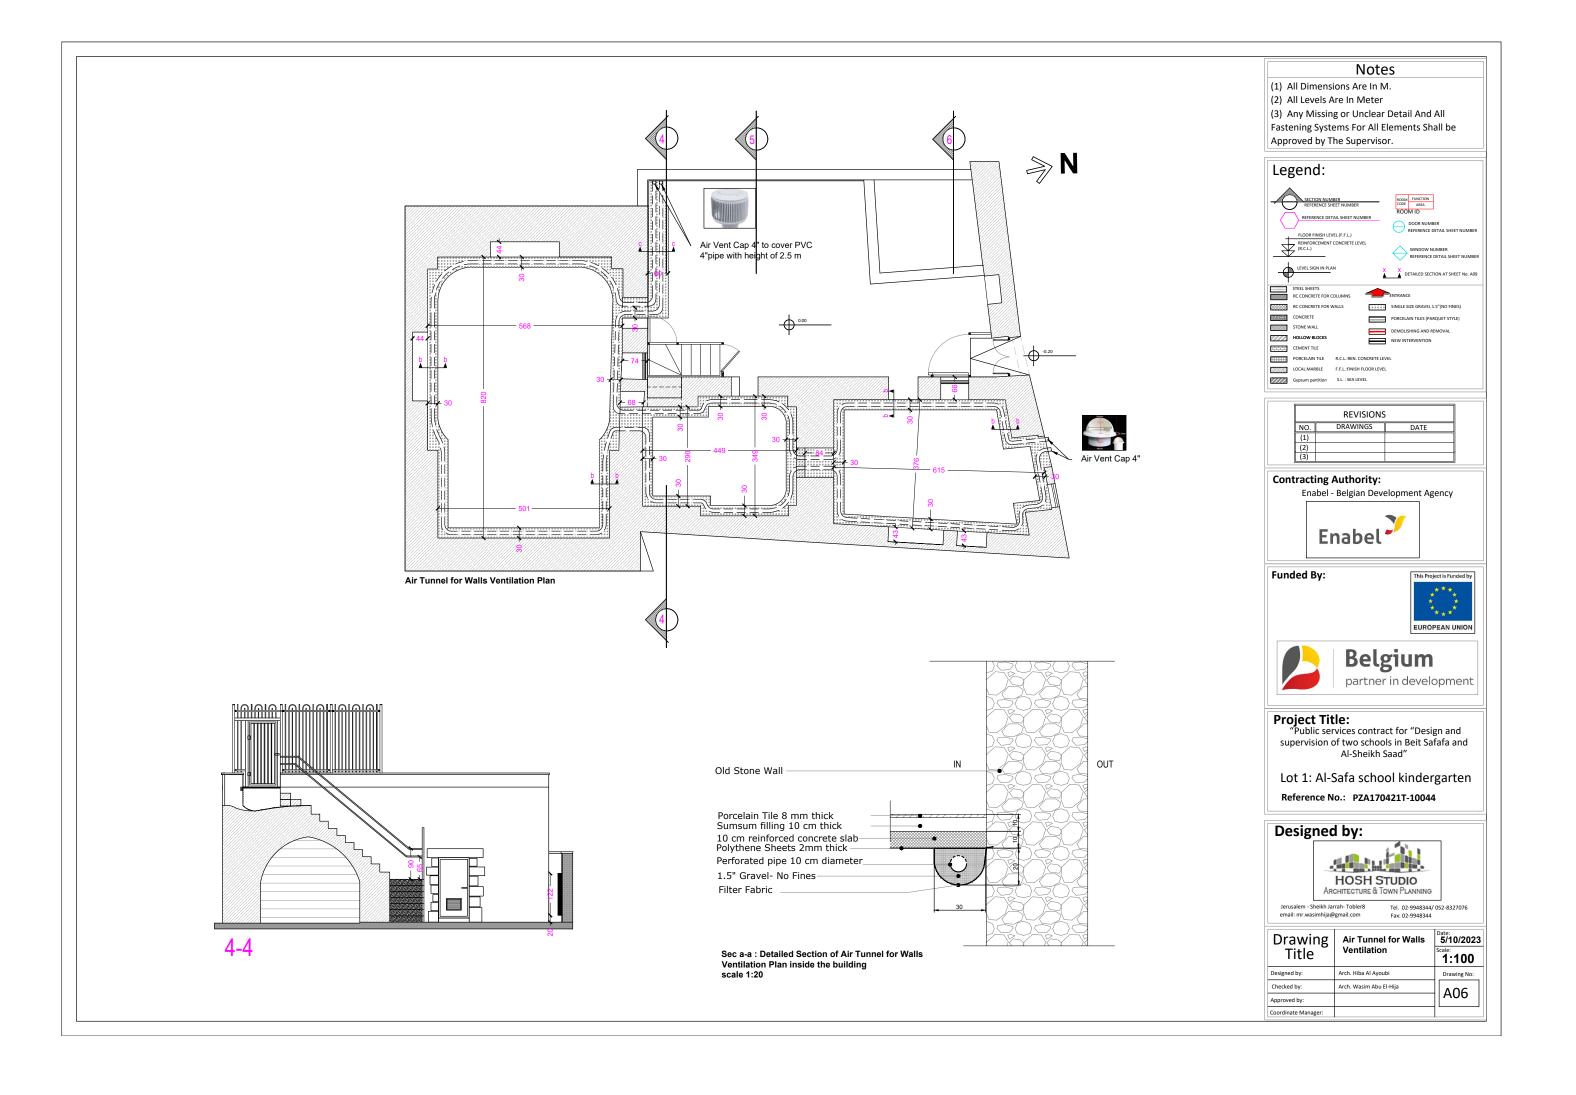

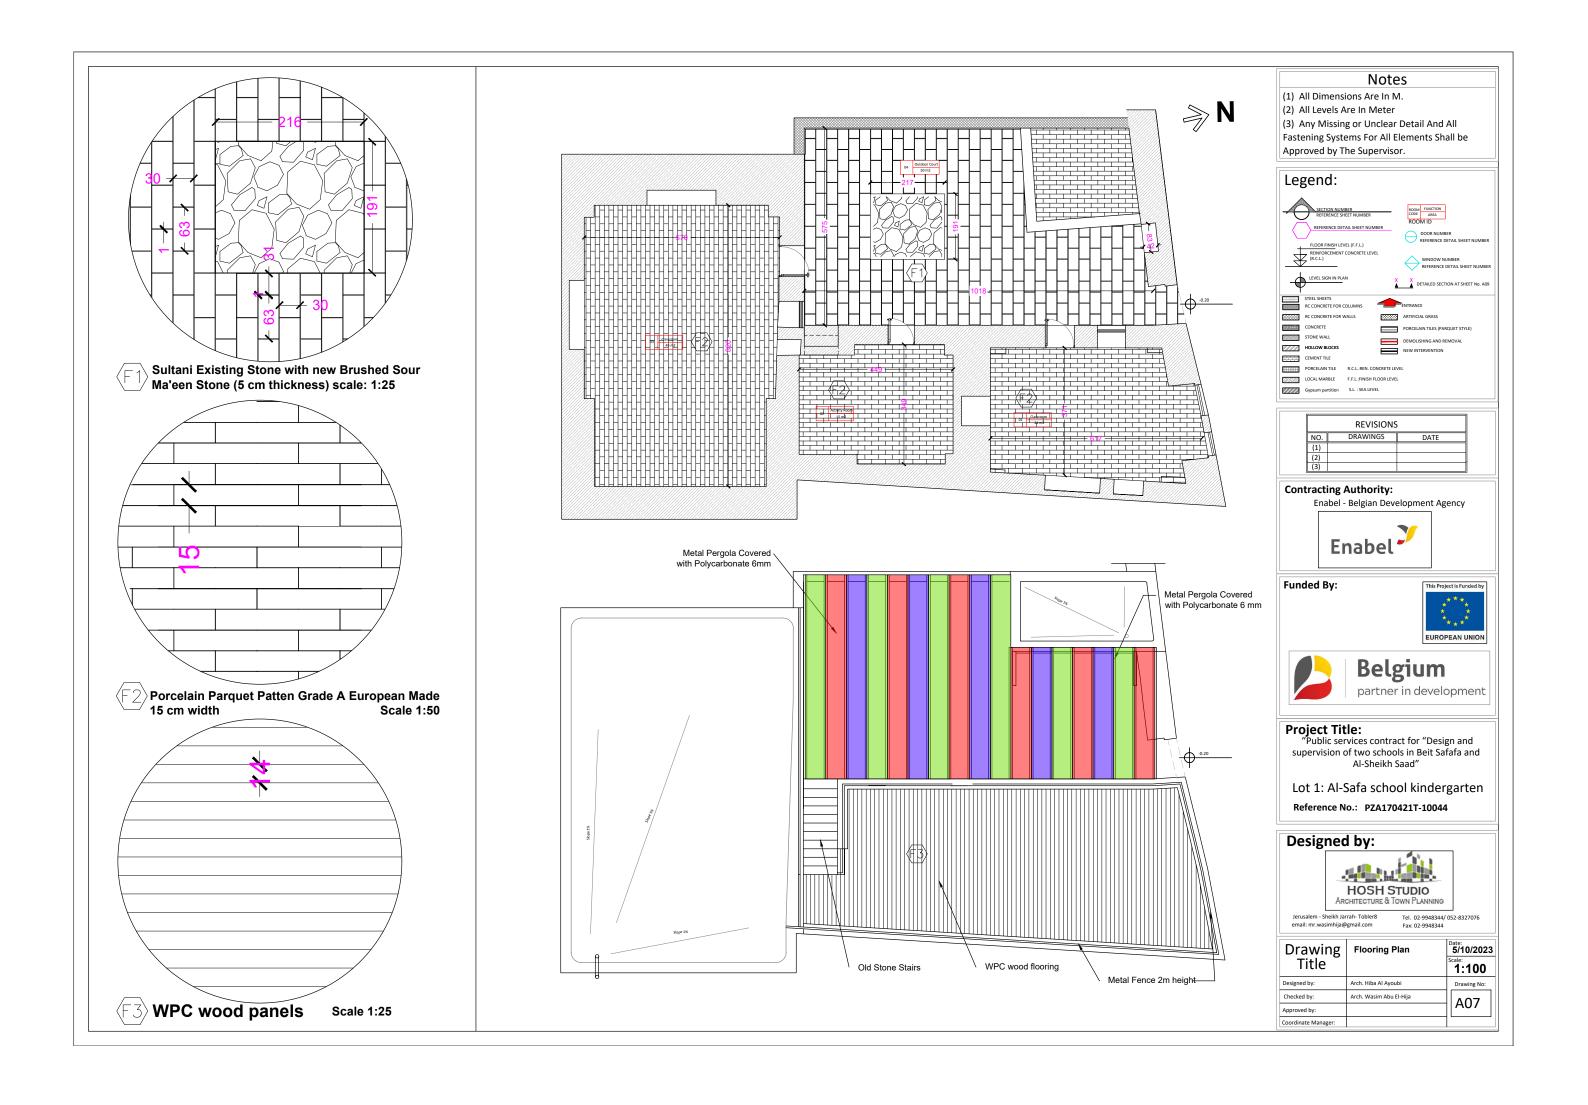

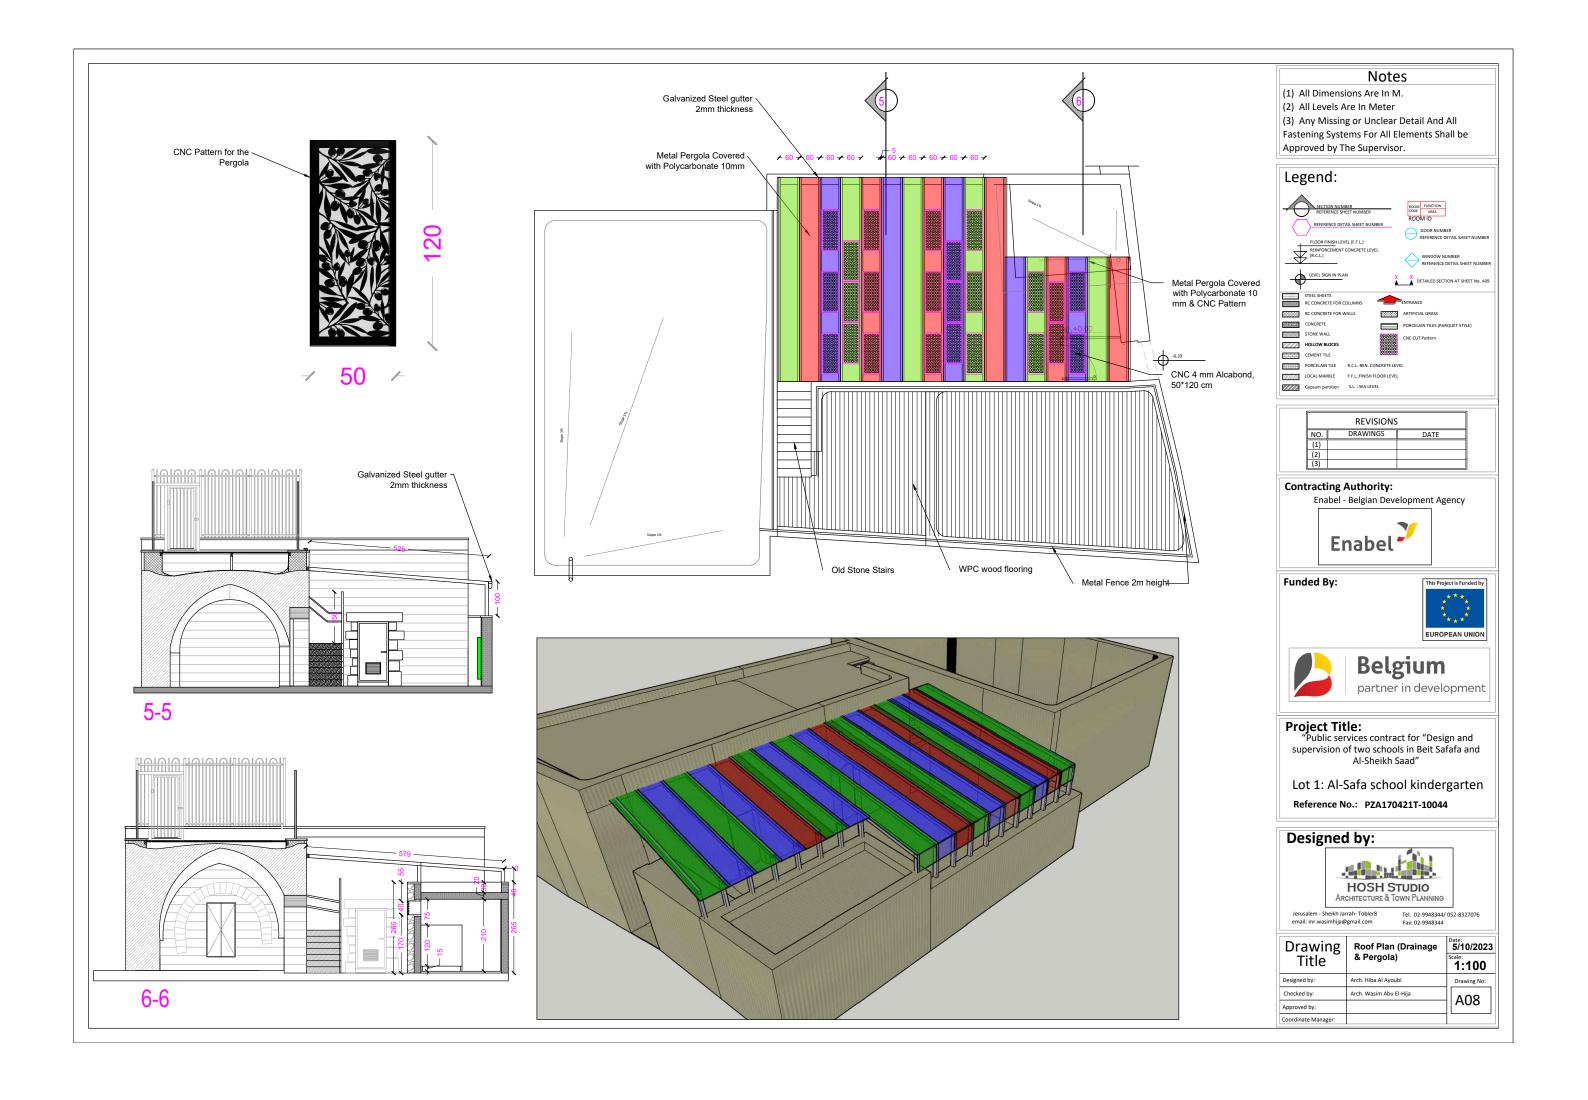

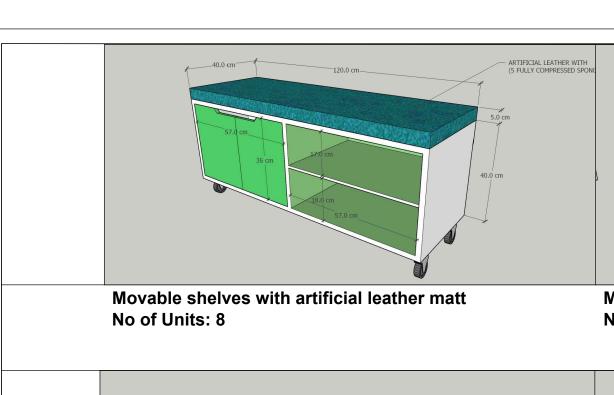



Movable shelves with with drawers No of Units: 2

Legend: RC CONCRETE CONCRETE STONE WALL

HOLLOW BLOCKS

CEMENT TILE PORCELAIN TILE LOCAL MARBLE F.F.L.:FINISH FLOOR LEVEL Gypsum partition S.L. : SEA LEVEL


(2) Submitting Shop drawings for all furniture (3) Any Missing or Unclear Detail And All Fastening Systems For All Elements Shall be

(1) All Dimensions Are In M.


Approved by The Supervisor.

|--|

Shelve complex (3 units with different colors) No of Units: 2

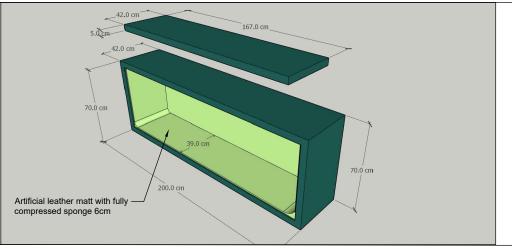

 Shelve complex (2 units with leather matt inside) No of Units: 2




Contracting Authority: Enabel - Belgian Development Agency Enabel


Funded By:





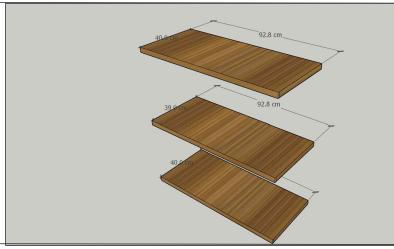

Shelve complex (3 shelves for each opening) No of Units: 3- dimensions according to each opening in site

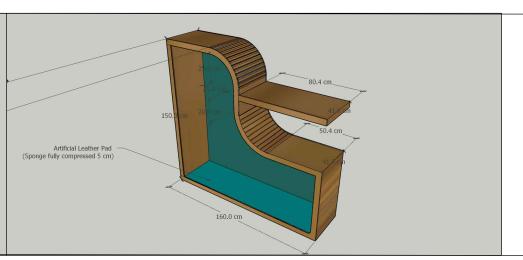

Shelve complex (2 units with leather matt inside) No of Units:1

Project Title:

"Public services contract for "Design and supervision of two schools in Beit Safafa and Al-Sheikh Saad"

Lot 1: Al-Safa school kindergarten Reference No.: PZA170421T-10044


Designed by:





email: mr.wasimhija@gmail.com


Tel. 02-9948344/ 052-8327076

Drawing	Furniture details	5/10/2023
Title		Scale:
Designed by:	Arch. Hiba Al Ayoubi	Drawing No:
Checked by:	Arch. Wasim Abu El-Hija	A09
Approved by:		AU9
Coordinate Manager:		

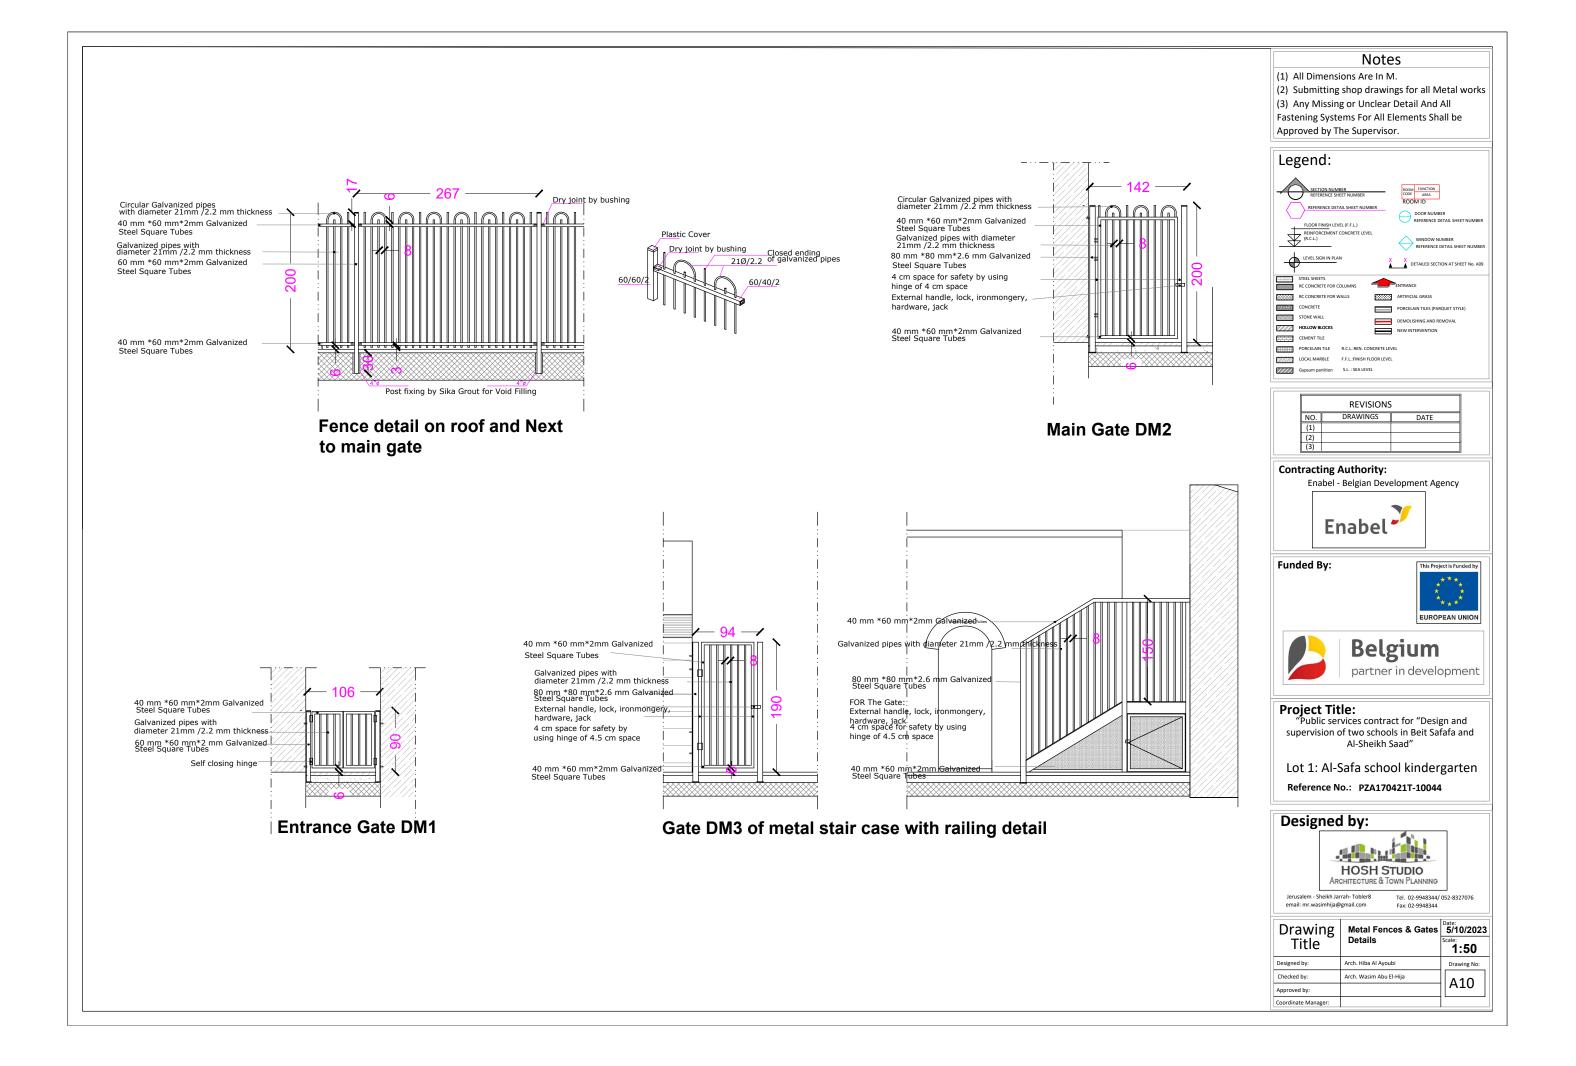

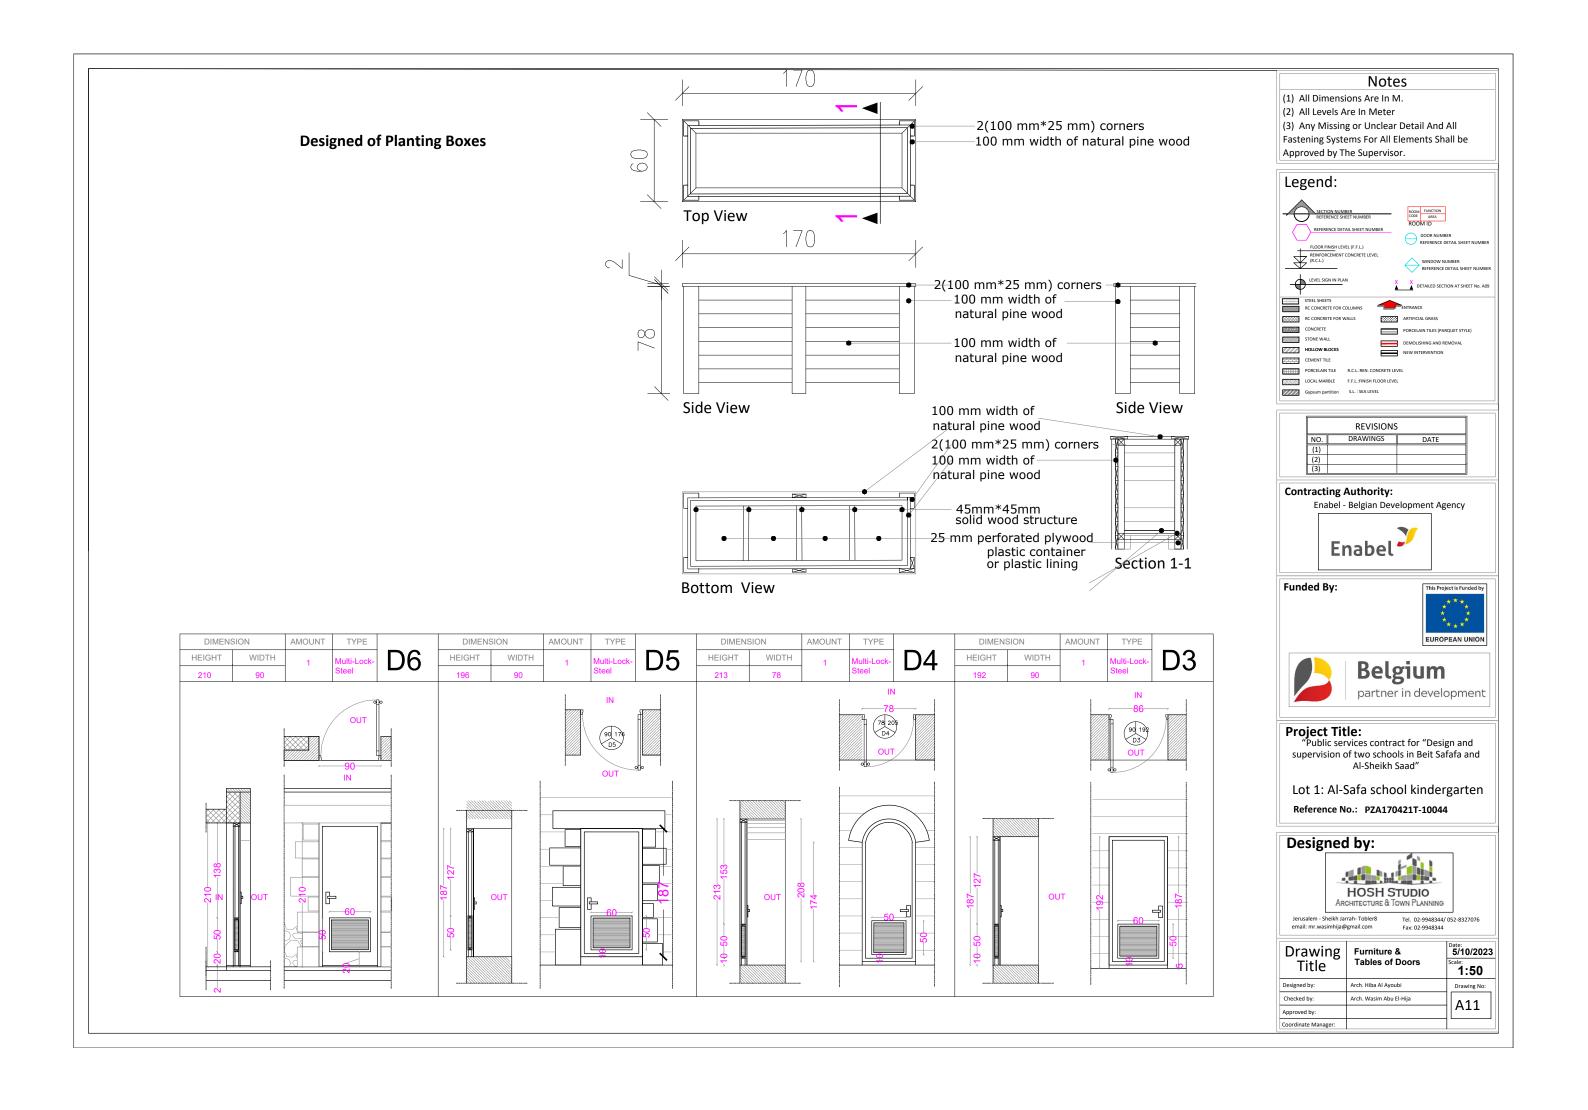

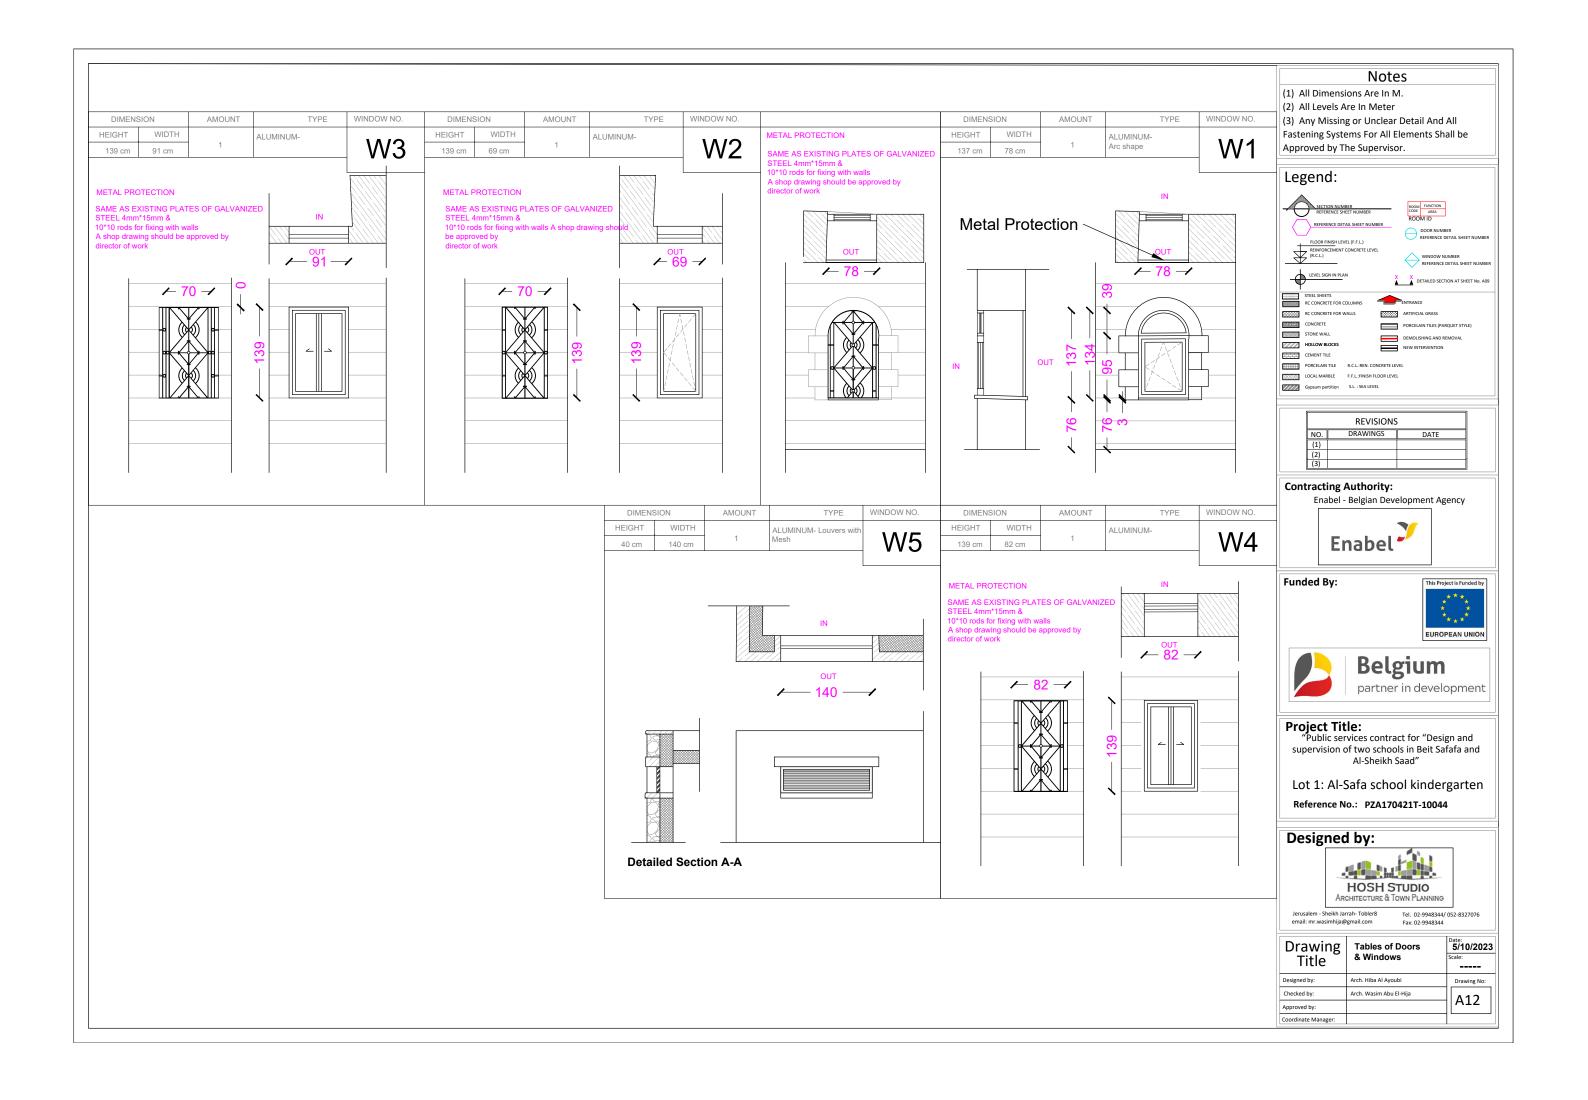

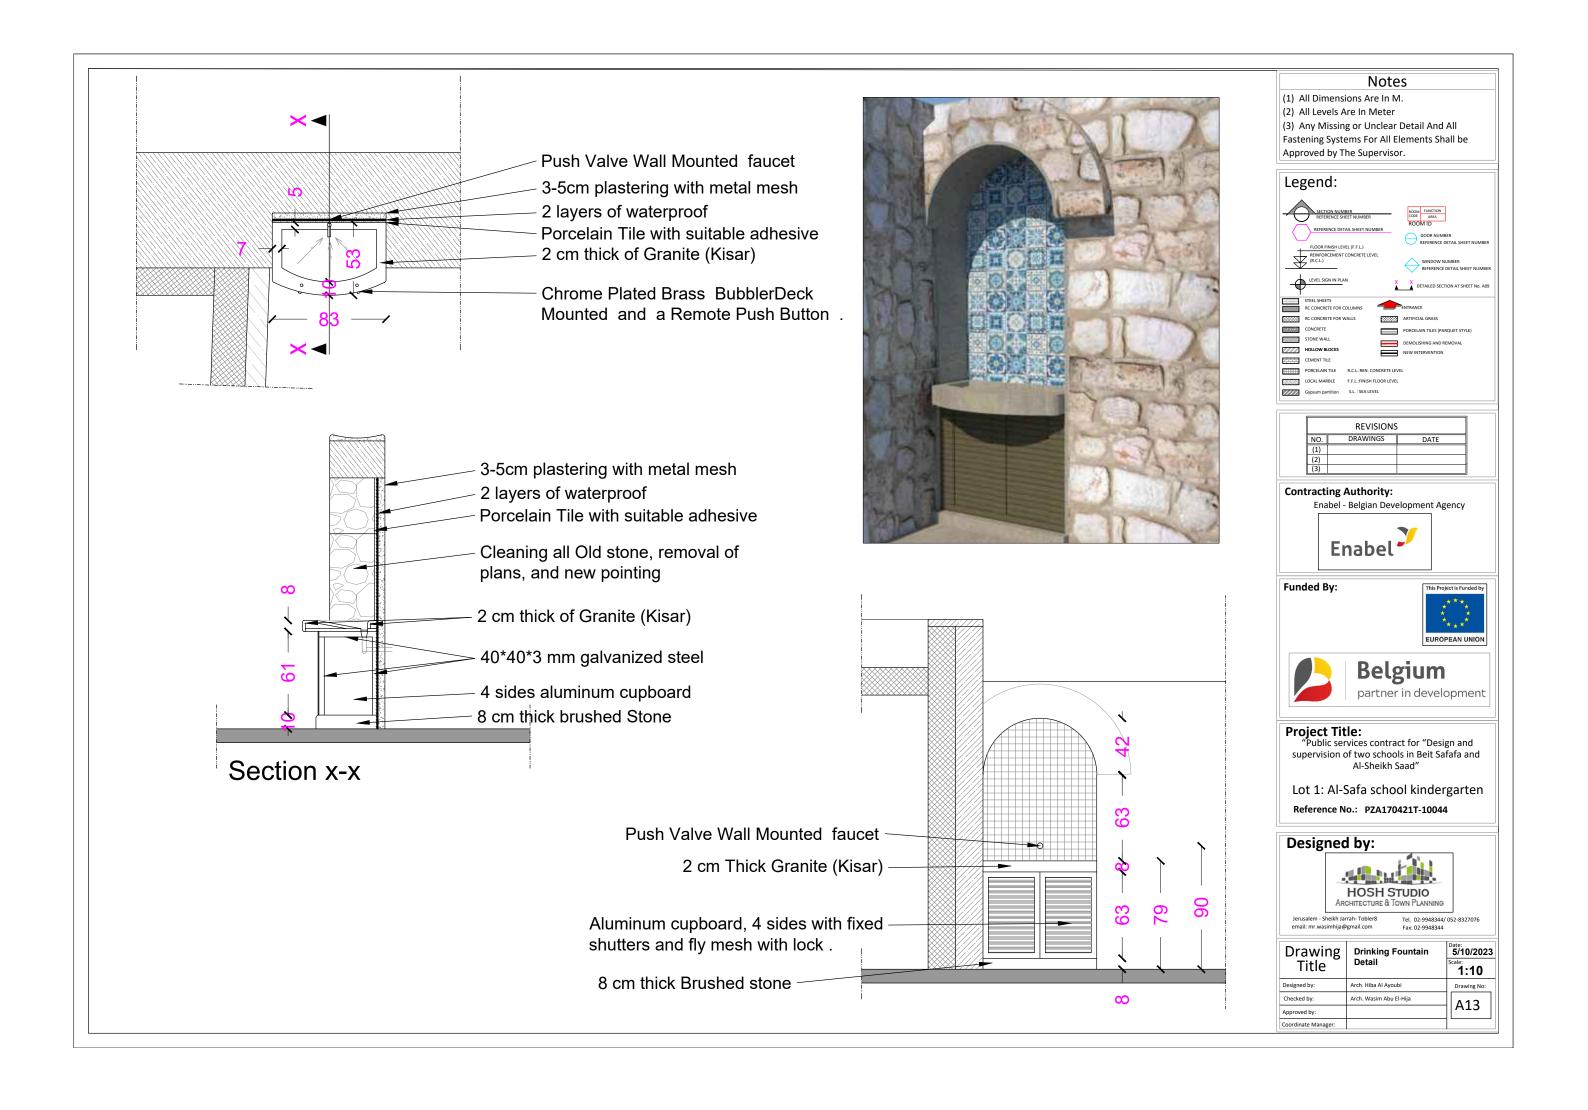


"THE CREATION OF AL-SAFA KINDERGARTEN AND THE REHABILITATION OF AL-SAFA BASIC SCHOOL IN BEIT SAFAFA"


Al-Safa school kindergarten


Reference No.: PZA170421T-10055


Structural Drawings




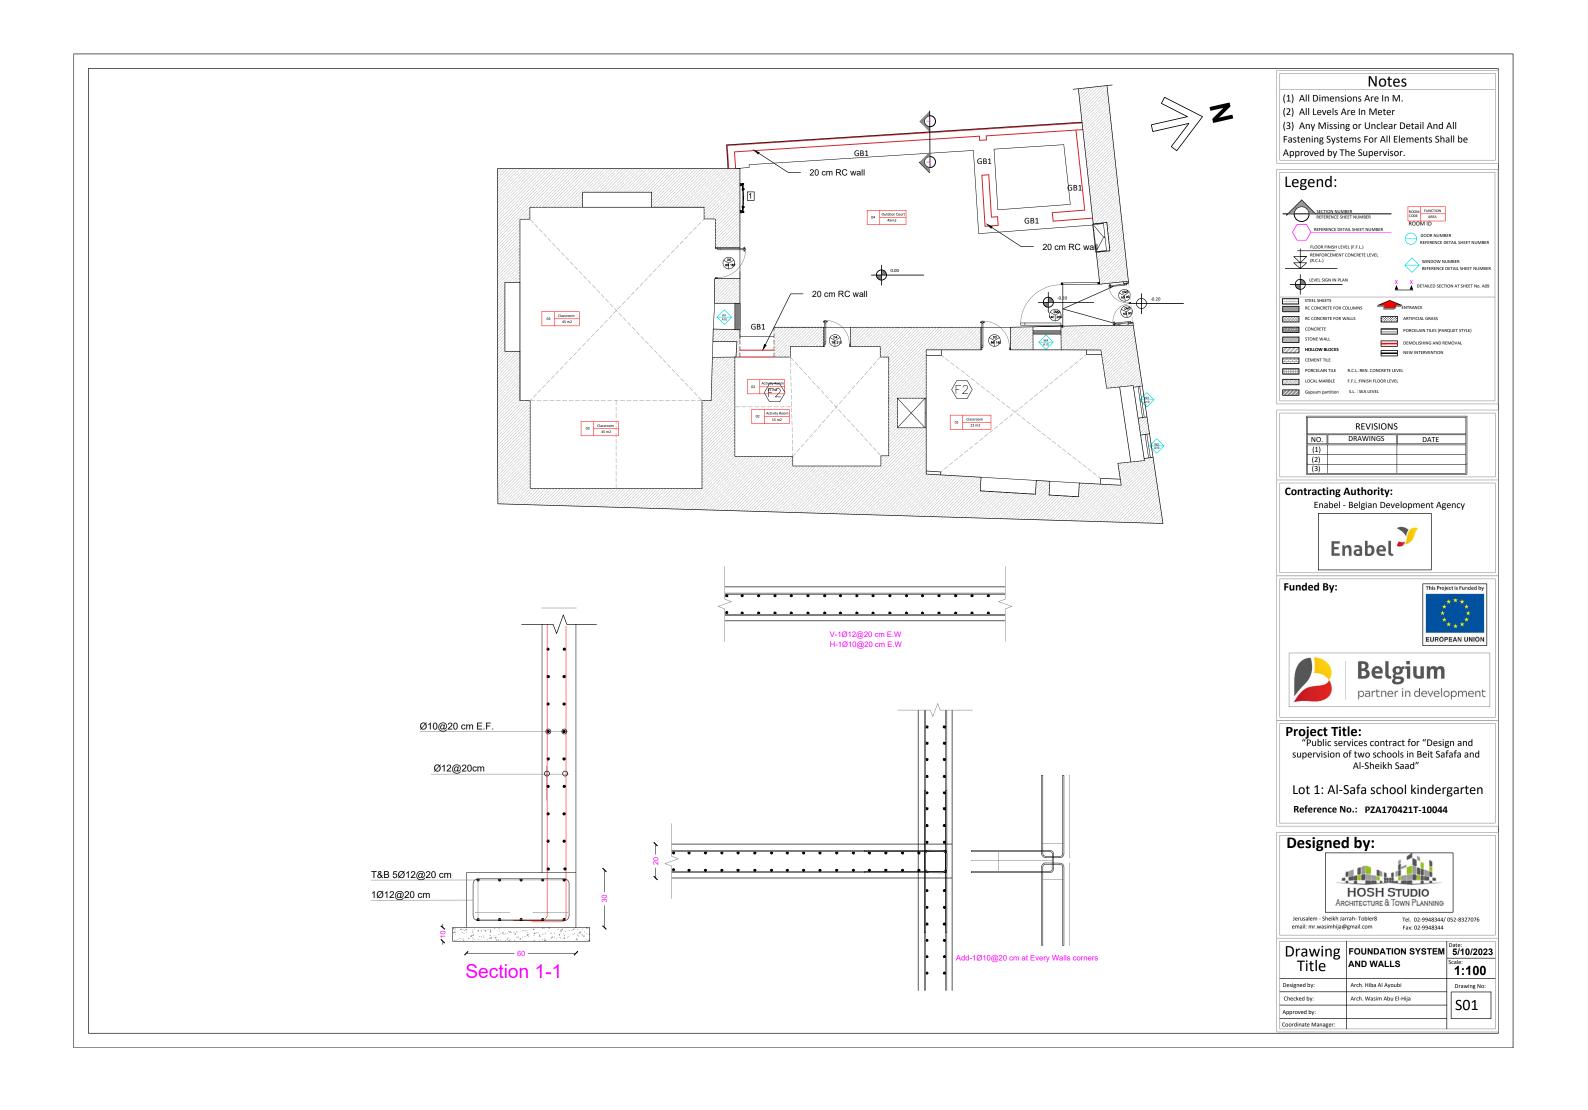

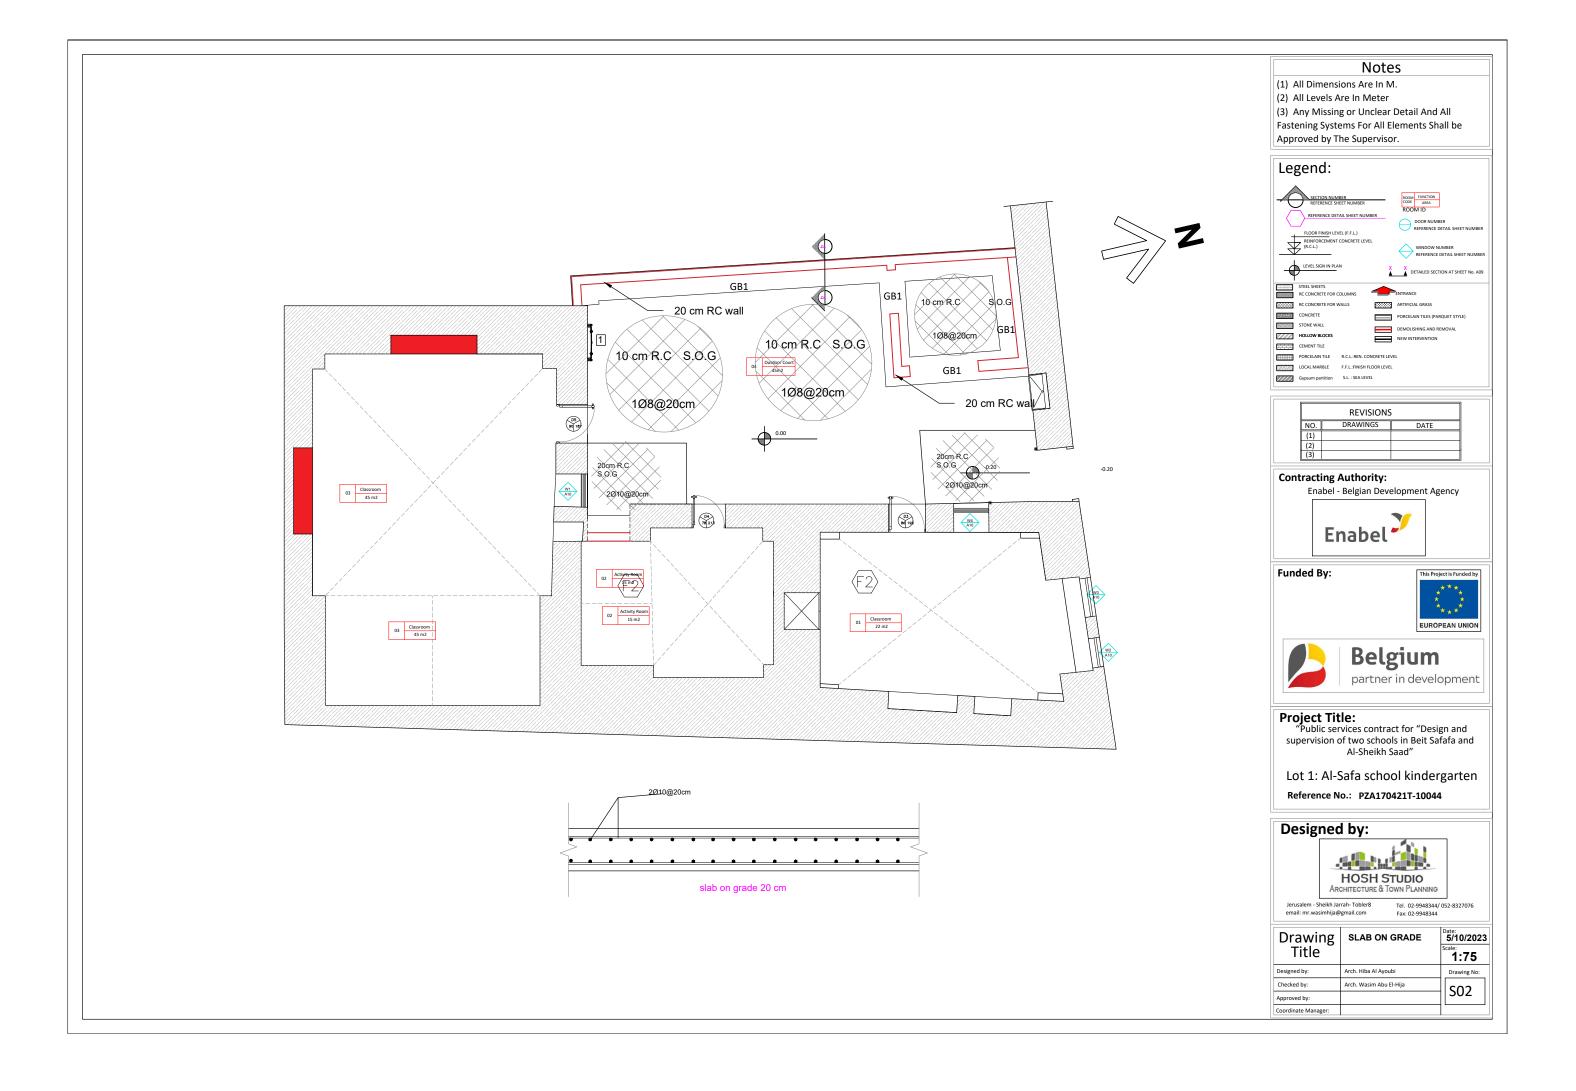

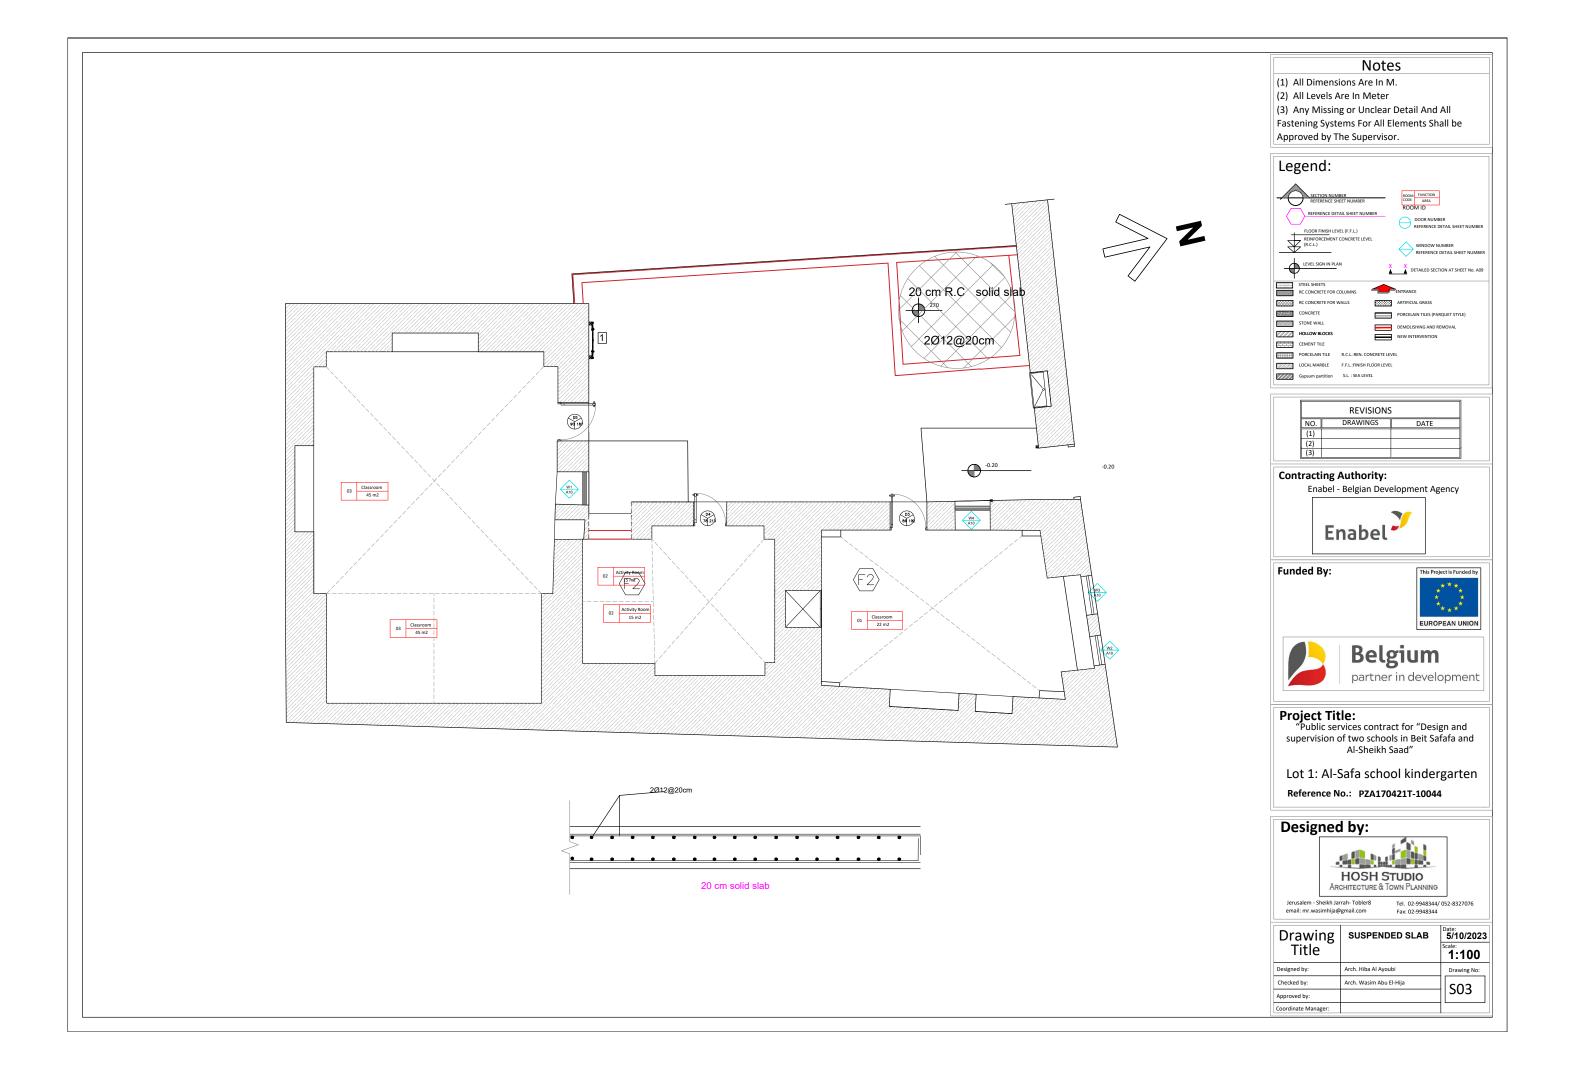

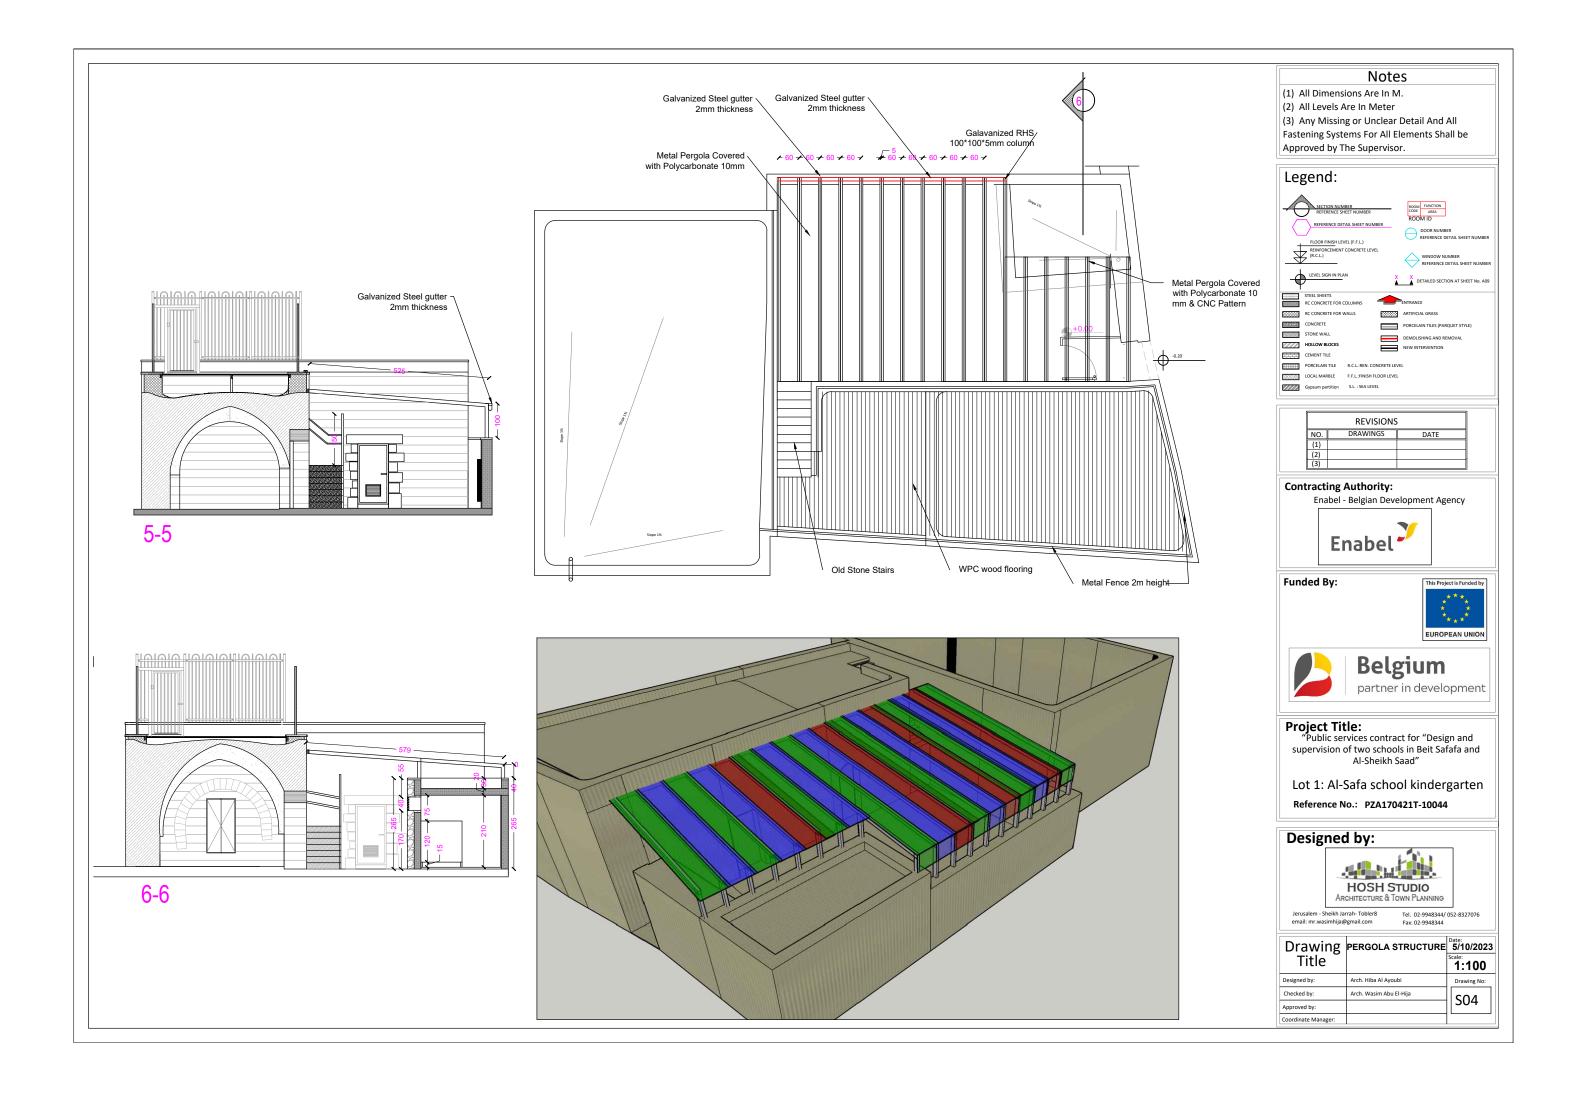

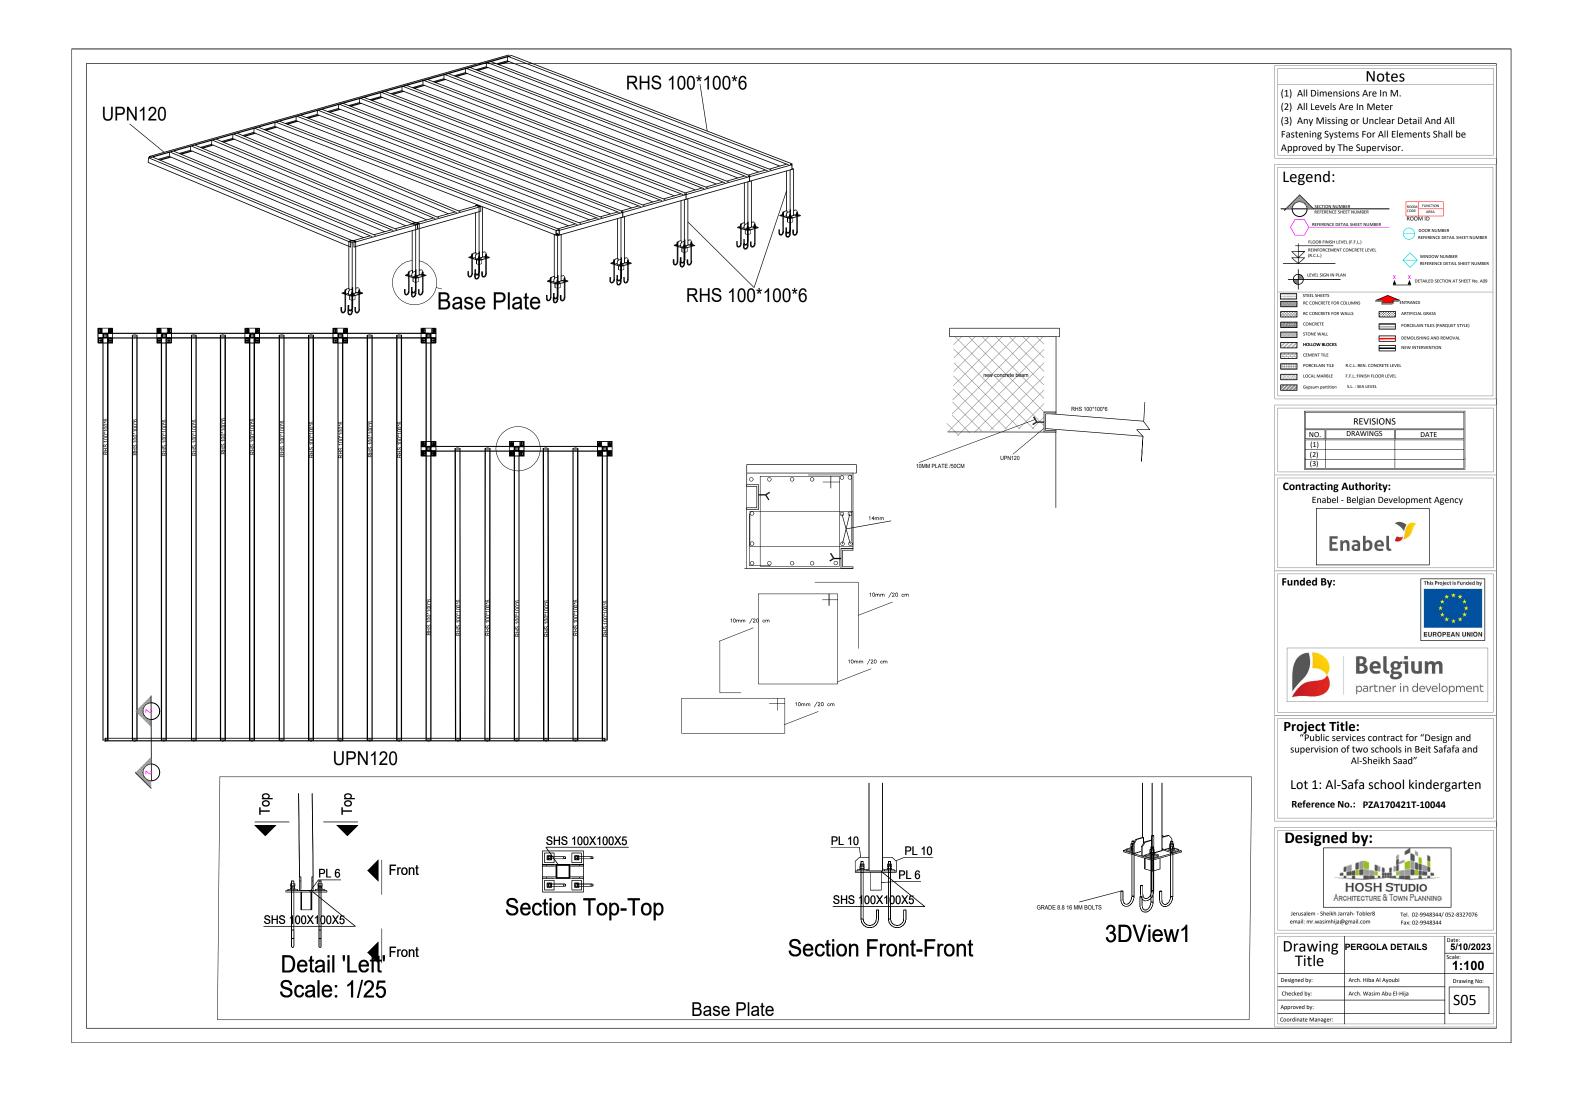

"THE CREATION OF AL-SAFA KINDERGARTEN AND THE REHABILITATION OF AL-SAFA BASIC SCHOOL IN BEIT SAFAFA"

Al-Safa school kindergarten

Reference No.: PZA170421T-10055

Mechanical Drawings







4" Roof Rain Free Discharge 20 cm Above Street


Connected To Municipality Manhole

4" Roof Rain Free Discharge 20 cm Above Street

4" Roof Rain Free Discharge 20 cm Above Street

Notes

- (1) All Dimensions Are In cm.
- (2) All Levels Are In cm
- (3) Any Missing or Unclear Detail And All Fastening Systems For All Elements Shall be Approved by The Supervisor.

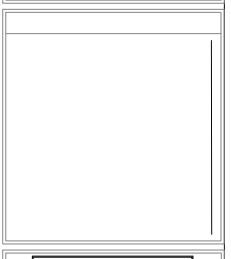

	REVISIONS	;
NO.	DRAWINGS	DATE
(1)		
(2)		
(3)		

Contracting Authority:

Enabel - Belgian Development Agency



Funded By:





Belgium partner in development

Project Title:

"Public services contract for "Design and supervision of two schools in Beit Safafa and Al-Sheikh Saad"


Lot 1: Al-Safa school kindergarten Reference No.: PZA170421T-10044

Designed by:




Jerusalem - Sheikh Jarrah- Tobler8 email: mr.wasimhija@gmail.com

Drawing Title	Drainage System	Date: 11/2023 Scale: 1:75
Designed by:	Eng. Mohammad Salah	Drawing No:
Checked by:	Eng. Wasim Abu El Hija	M01
Approved by:		
Coordinate Manager:		

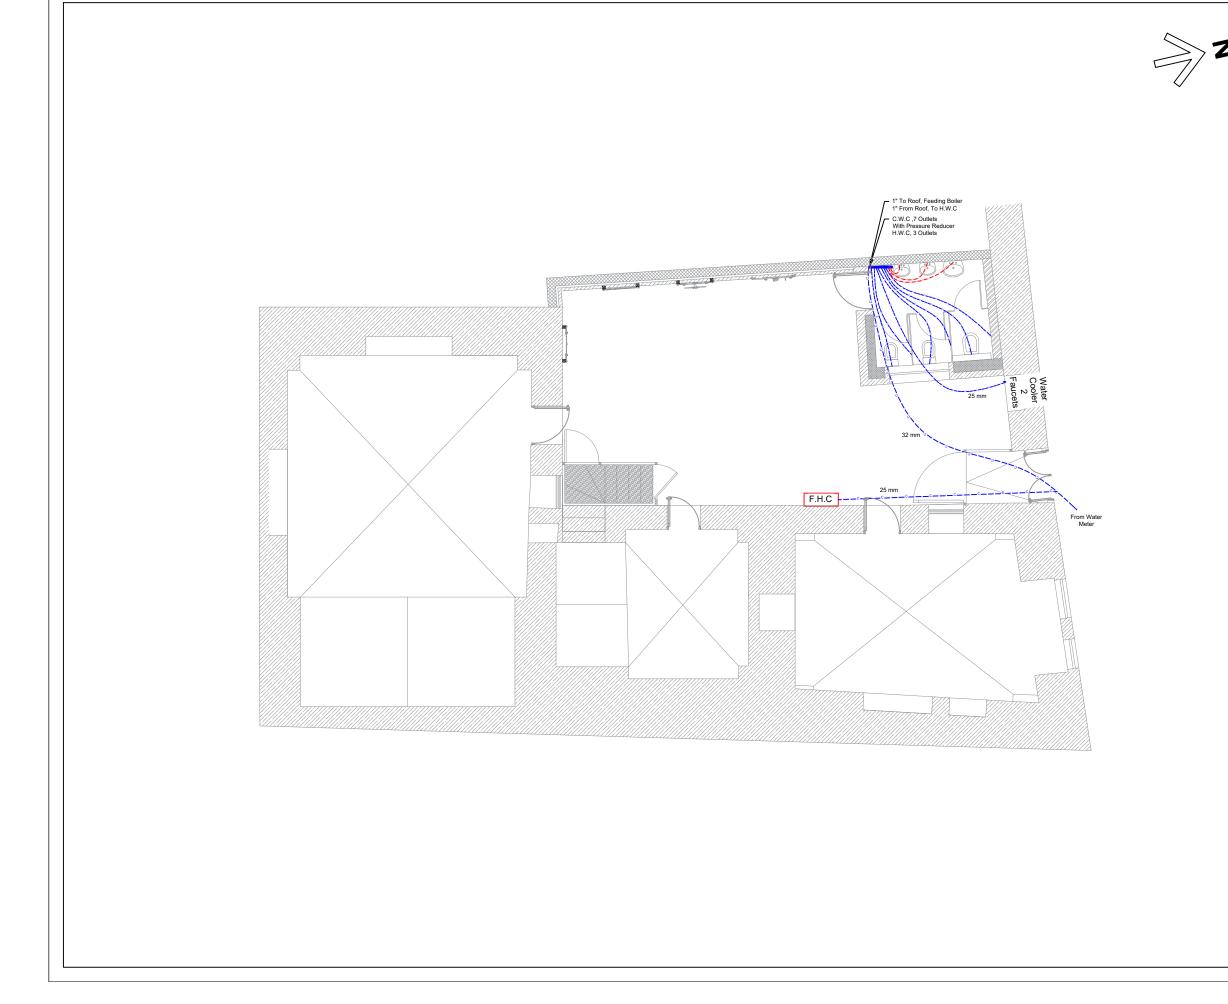

- (1) All Dimensions Are In cm.
- (2) All Levels Are In cm
- (3) Any Missing or Unclear Detail And All Fastening Systems For All Elements Shall be Approved by The Supervisor.

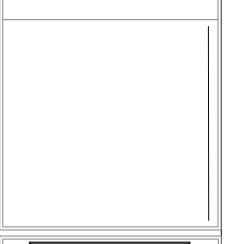

	REVISIONS	5
NO.	DRAWINGS	DATE
(1)		
(2)		
(3)		

Contracting Authority:

Enabel - Belgian Development Agency



Funded By:





Belgium partner in development

Project Title:

"Public services contract for "Design and supervision of two schools in Beit Safafa and Al-Sheikh Saad"

Lot 1: Al-Safa school kindergarten Reference No.: PZA170421T-10044

Designed by:




Jerusalem - Sheikh Jarrah- Tobler8 email: mr.wasimhija@gmail.com

Drawing Title	Water Supply System	Date: 11/2023 Scale: 1:75
Designed by:	Eng. Mohammad Salah	Drawing No:
Checked by:	Eng. Wasim Abu El Hija	M02
Approved by:		
Coordinate Manager:		



- (1) All Dimensions Are In cm.
- (2) All Levels Are In cm
- (3) Any Missing or Unclear Detail And All Fastening Systems For All Elements Shall be Approved by The Supervisor.

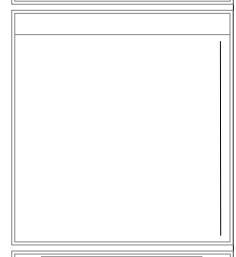

	REVISIONS	5
NO.	DRAWINGS	DATE
(1)		
(2)		
(3)		

Contracting Authority:

Enabel - Belgian Development Agency



Funded By:





Project Title:

"Public services contract for "Design and supervision of two schools in Beit Safafa and Al-Sheikh Saad"


Lot 1: Al-Safa school kindergarten Reference No.: PZA170421T-10044

Designed by:




Jerusalem - Sheikh Jarrah- Tobler8 email: mr.wasimhija@gmail.com

Drawing Title	Ventilation and Air Conditioning System	Date: 11/2023 Scale: 1:75
Designed by:	Eng. Mohammad Salah	Drawing No:
Checked by:	Eng. Wasim Abu El Hija	M03
Approved by:		ן בטועו ןן
Coordinate Manager:		

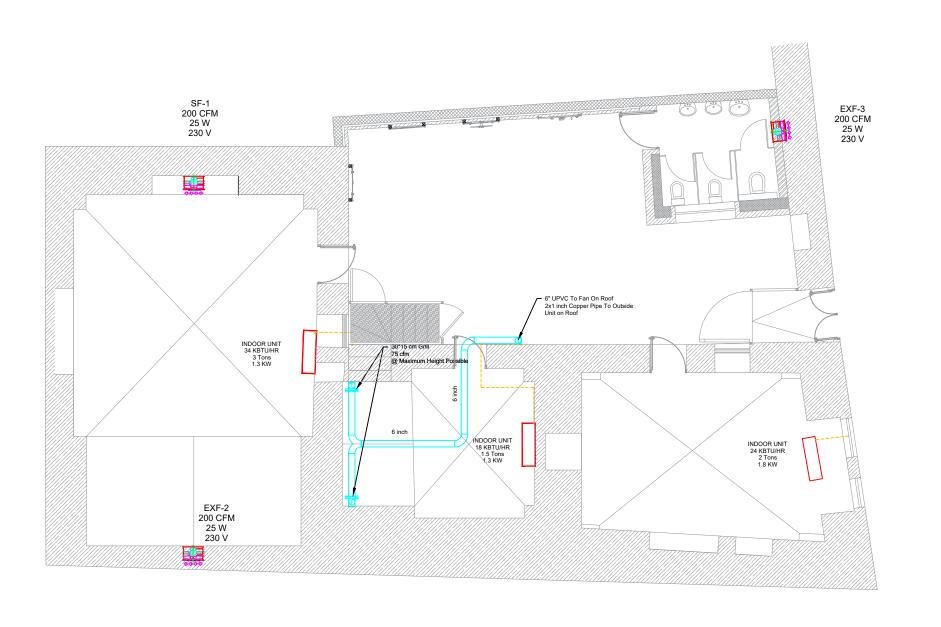



- (1) All Dimensions Are In cm.
- (2) All Levels Are In cm
- (3) Any Missing or Unclear Detail And All Fastening Systems For All Elements Shall be Approved by The Supervisor.

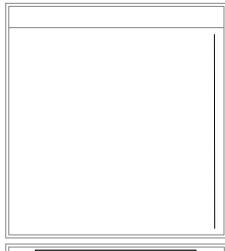

	REVISIONS	5
NO.	DRAWINGS	DATE
(1)		
(2)		
(3)		

Contracting Authority:

Enabel - Belgian Development Agency



Funded By:





Project Title:

"Public services contract for "Design and supervision of two schools in Beit Safafa and Al-Sheikh Saad"


Lot 1: Al-Safa school kindergarten Reference No.: PZA170421T-10044

Designed by:



Jerusalem - Sheikh Jarrah- Tobler8 email: mr.wasimhija@gmail.com

Drawing Title	ROOF Plan	Date: 11/2023 Scale: 1:75
Designed by:	Eng. Mohammad Salah	Drawing No:
Checked by:	Eng. Wasim Abu El Hija	M04
Approved by:		IVIU4
Coordinate Manager:		

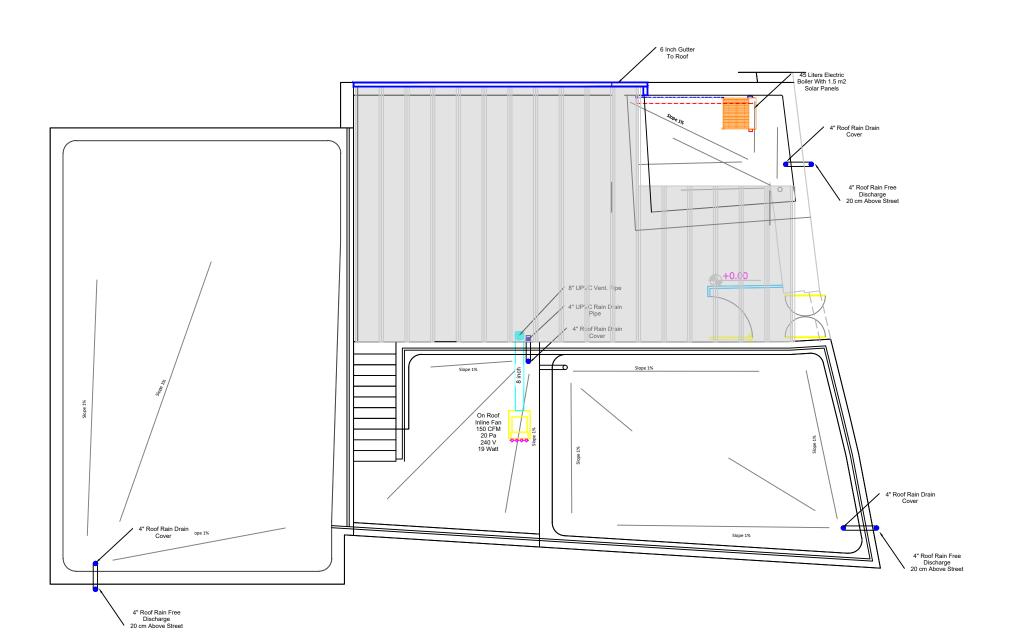


"THE CREATION OF AL-SAFA KINDERGARTEN AND THE REHABILITATION OF AL-SAFA BASIC SCHOOL IN BEIT SAFAFA"

Al-Safa school kindergarten

Reference No.: PZA170421T-10055

Electrical Drawings



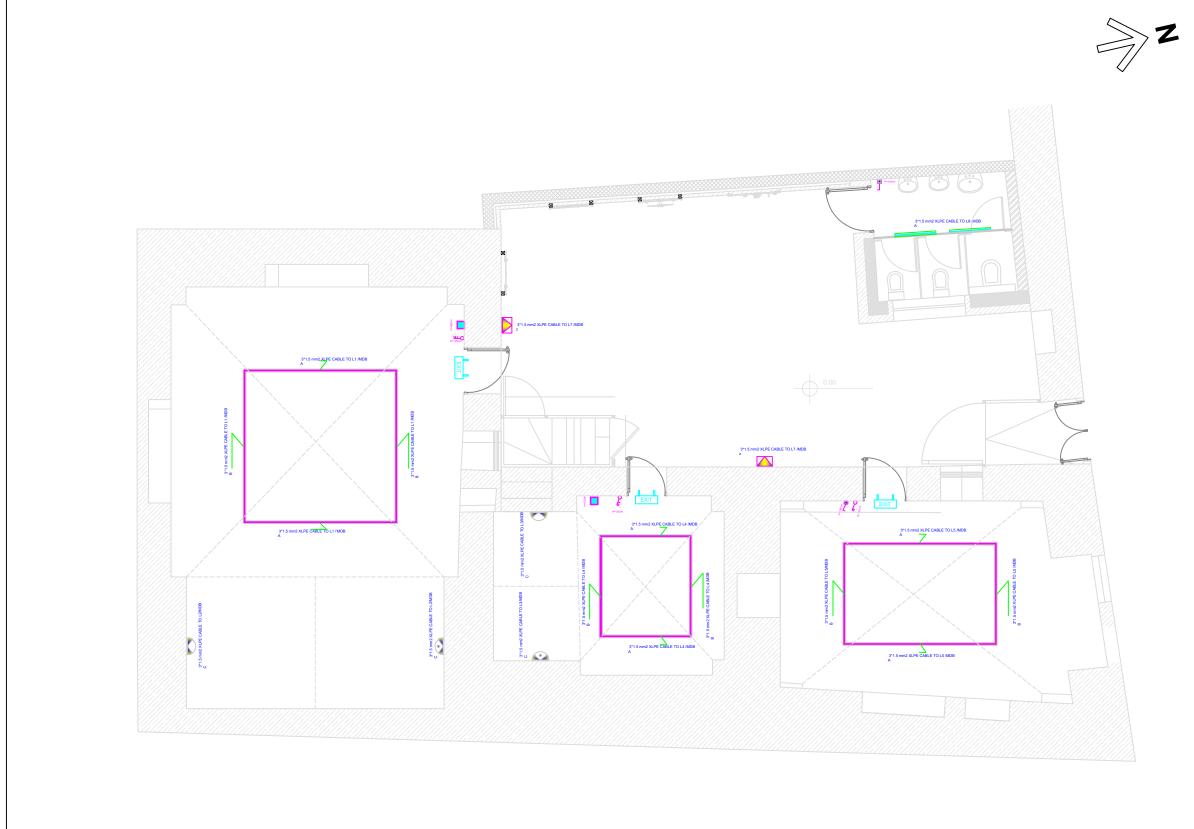

- (1) All Dimensions Are In cm.
- (2) All Levels Are In cm
- (3) Any Missing or Unclear Detail And All Fastening Systems For All Elements Shall be Approved by The Supervisor.

Legend:

SYMBOL	DESCRIPTION
SIMDUL	LIGHTING FIXTURE & SWITCHES
<u> </u>	Indicator lamp
	LED floodlight Projector IP65
D	WALL MOUNTED LIGHTING FIXTURE
•	WALL MOUNTED LIGHTING FIXTURE FOR EXTERNAL USE IP65
(===	Celing suspended lighting LED Fixture
	WP. IP65, 6500K, 39 watt, 4400 lm poly-carbonate surface mount lighting fixture
	JUNCTION BOX
EXIT	LED TYPE WITH EXIT SIGN AND ARROWS EMERGENCY LIGHTING FIX.
î î	SINGLE POLE ONE GANG SWITCH / W.P.
11	SINGLE POLE TWO GANG SWITCH / W.P.
8.8	SINGLE POLE THREE GANG SWITCH / W.P.
£ # #	DOUBLE POLE SWITCH WITH INDICATOR LAMP / W.P.

	REVISIONS	5
NO.	DRAWINGS	DATE
(1)		
(2)		
(3)		

Contracting Authority:

Enabel - Belgian Development Agency



Funded By:





Project Title:

"Public services contract for "Design and supervision of two schools in Beit Safafa and Al-Sheikh Saad"


Lot 1: Al-Safa school kindergarten Reference No.: PZA170421T-10044

Designed by:



Jerusalem - Sheikh Jarrah- Tobler8 email: mr.wasimhija@gmail.com

Drawing Title	Proposed Lighting	Date: 11/2023 Scale: 1:75
Designed by:	Eng. Adli Naser AL Deen	Drawing No:
Checked by:	Eng. Midhat Al Shareef	E01
Approved by:		
Coordinate Manager:]

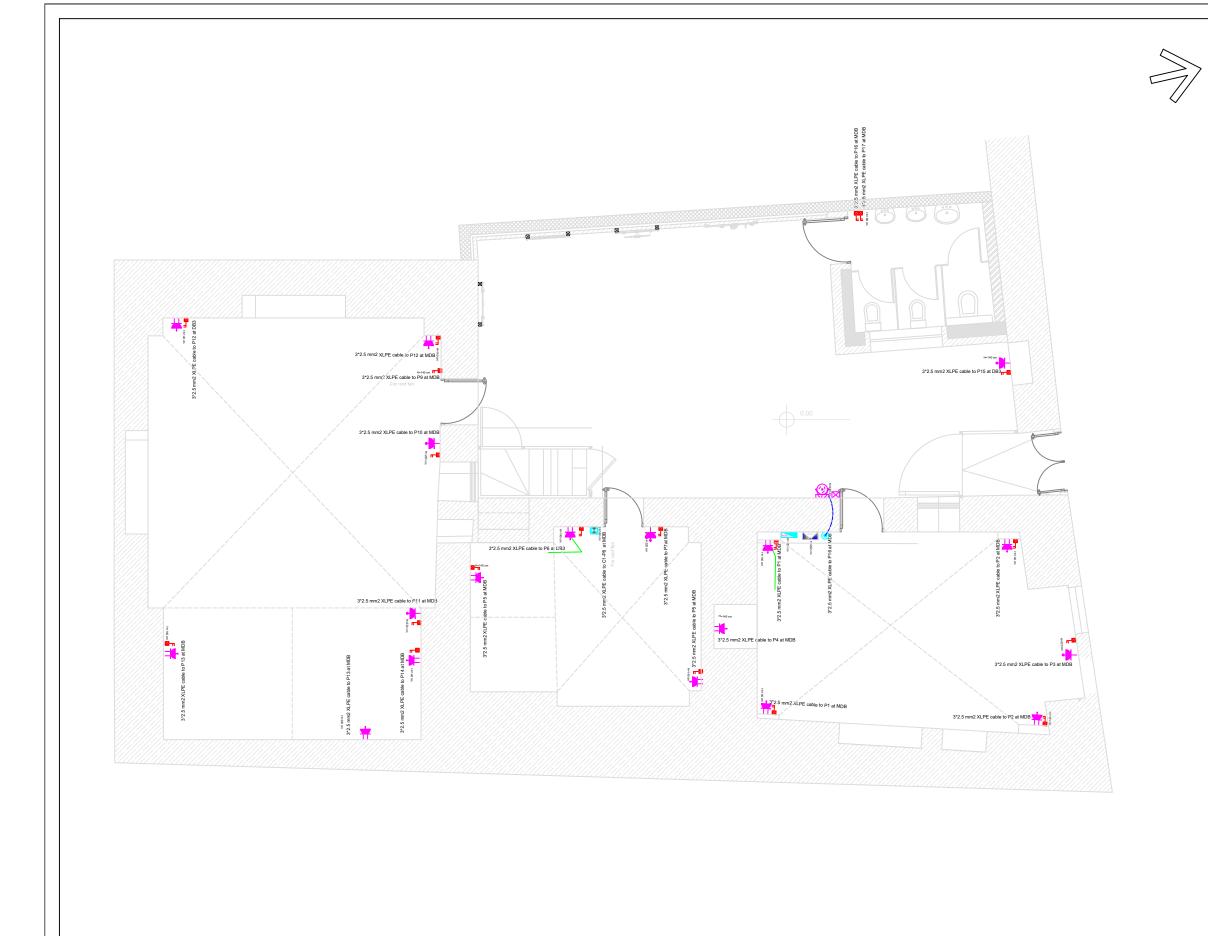

- (1) All Dimensions Are In cm.
- (2) All Levels Are In cm
- (3) Any Missing or Unclear Detail And All Fastening Systems For All Elements Shall be Approved by The Supervisor.

Legend:

SYMBOL	DESCRIPTION	
SIMBUL	POWER SOCKETS	
-#+	16A 3 PIN SOCKET OUTLET / W.P.	
#	16A 3 PIN TWIN SOCKET OUTLET / W.P.	
#	16A 3 PIN TRIPLE SOCKET OUTLET	
r 2 P	SINGLE PHASE (2POLE) ISOLATOR, Rate As Indicated	
1.1	DOUBLE POLE SWITCH WITH INDICATOR LAMP / W.P.	
⊠	JUNCTION BOX	
	Indicator lamp	
Vices	Main Distribution Board (MDB)	
2004	Kilowatt-hour meter Board (KWH)	
<u> </u>	PUSH BUTTON	
Q	School Bell	

	REVISIONS	
NO.	DRAWINGS	DATE
(1)		
(2)		
(3)		

Contracting Authority:

Enabel - Belgian Development Agency



Funded By:





Project Title:

"Public services contract for "Design and supervision of two schools in Beit Safafa and Al-Sheikh Saad"


Lot 1: Al-Safa school kindergarten Reference No.: PZA170421T-10044

Designed by:



Jerusalem - Sheikh Jarrah- Tobler8 email: mr.wasimhija@gmail.com

Drawing Title	Proposed Power	Date: 11/2023 Scale: 1:75
Designed by:	Eng. Adli Naser AL Deen	Drawing No:
Checked by:	Eng. Midhat Al Shareef	E02
Approved by:		
Coordinate Manager:		

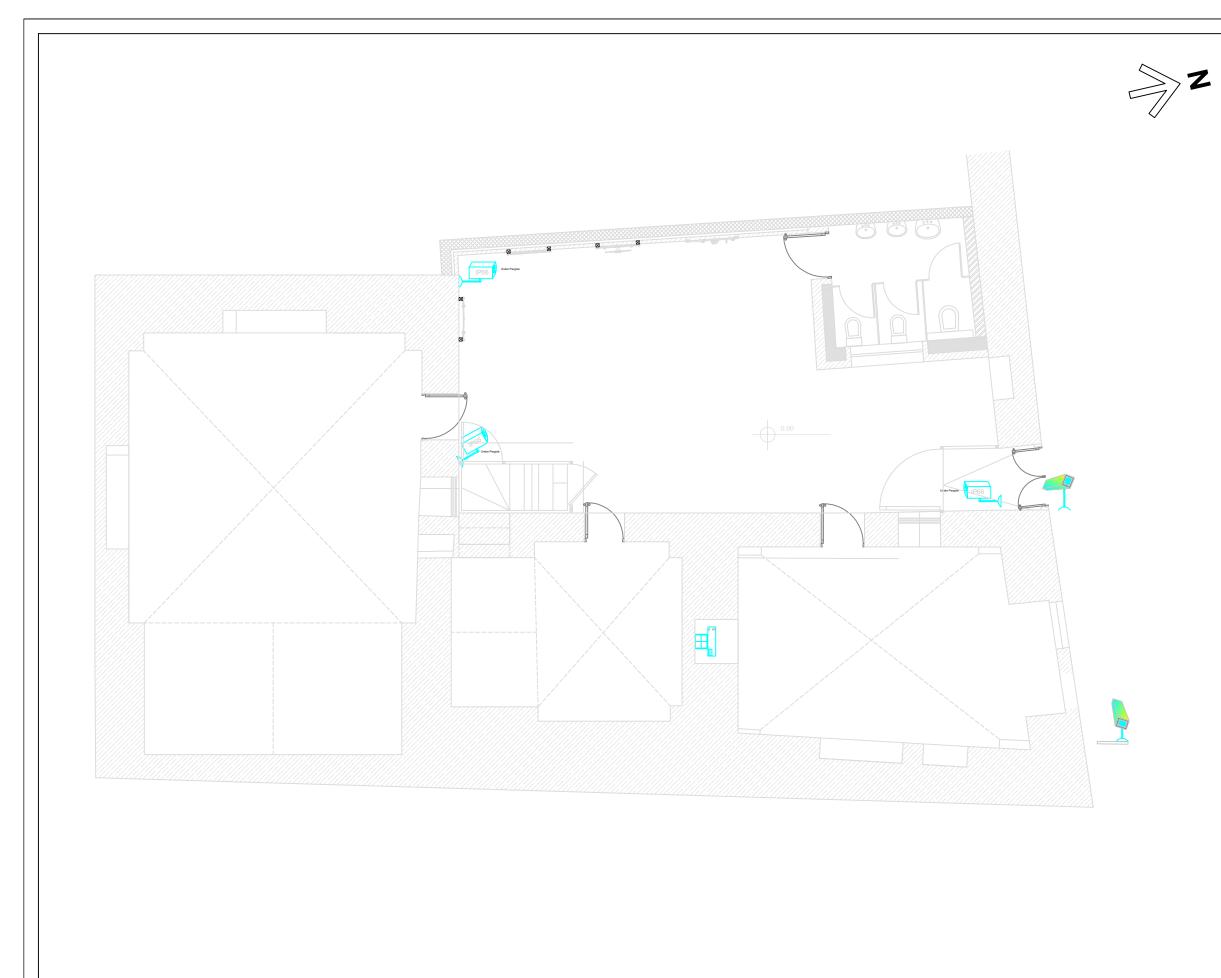

- (1) All Dimensions Are In cm.
- (2) All Levels Are In cm
- (3) Any Missing or Unclear Detail And All Fastening Systems For All Elements Shall be Approved by The Supervisor.

Legend:

SYMB0L	DESCRIPTION
STWIDOL	CCTV SYSTEM
\blacksquare	SPLIT SCREEN MONITOR
COO.	Network Video Recorder (NVR)
7 🗬	FIXED OUTDOOR COLORED CAMERA

	REVISIONS	i
NO.	DRAWINGS	DATE
(1)		
(2)		
(3)		

Contracting Authority:

Enabel - Belgian Development Agency



Funded By:





Belgium partner in development

Project Title:

"Public services contract for "Design and supervision of two schools in Beit Safafa and Al-Sheikh Saad"


Lot 1: Al-Safa school kindergarten Reference No.: PZA170421T-10044

Designed by:



Jerusalem - Sheikh Jarrah- Tobler8 email: mr.wasimhija@gmail.com

Drawing Title	Proposed CCTV (closed-circuit television)System	Date: 11/2023 Scale: 1:75
Designed by:	Eng. Adli Naser AL Deen	Drawing No:
Checked by:	Eng. Midhat Al Shareef	E03
Approved by:		7 503
Coordinate Manager:		

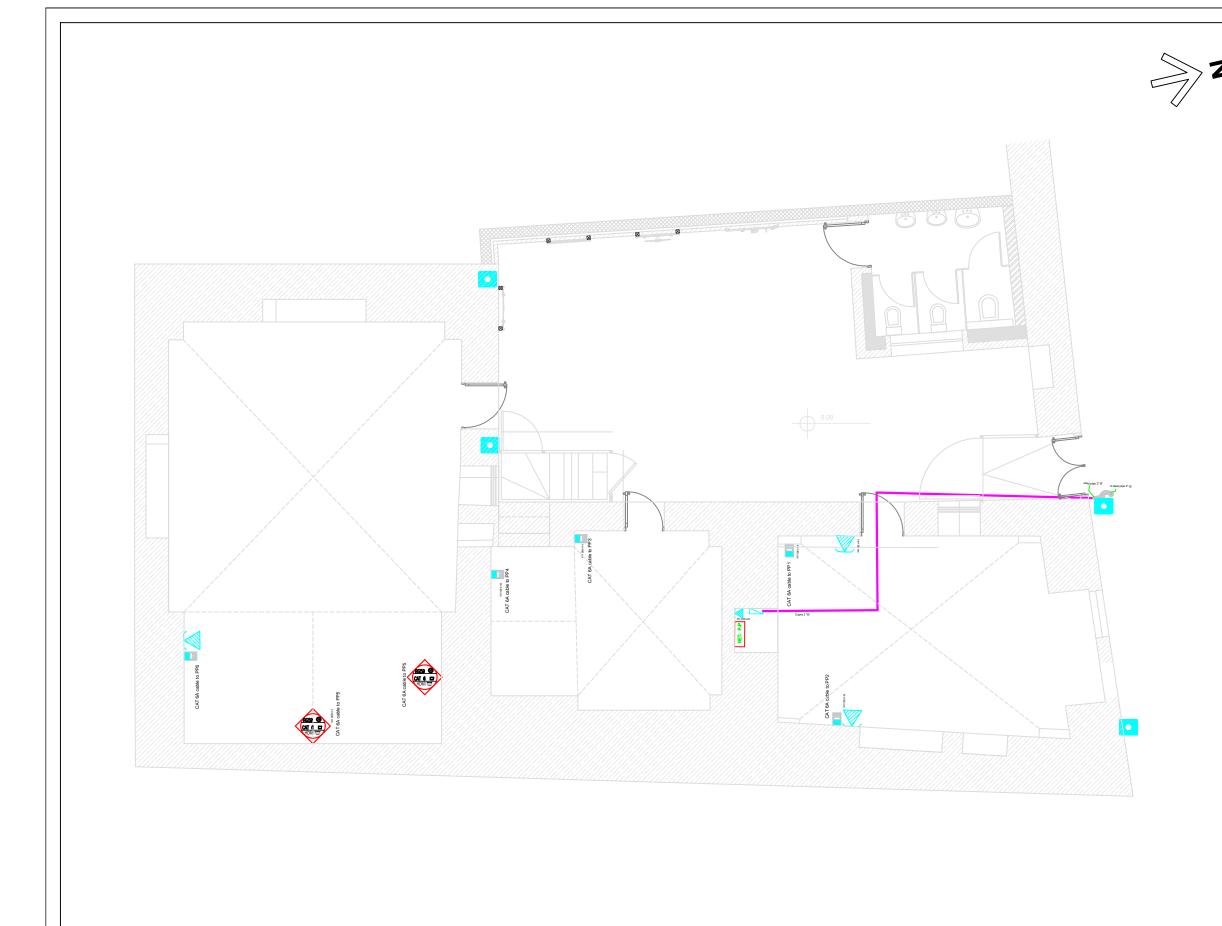

- (1) All Dimensions Are In cm.
- (2) All Levels Are In cm
- (3) Any Missing or Unclear Detail And All Fastening Systems For All Elements Shall be Approved by The Supervisor.

Legend:

SYMBOL	DESCRIPTION	
STWIDGE	L.V. SOCKETS	
	16A power socket,HDMI,Cat6A ,coaxial cable wall panel	
	DATA SOCKET OUTLET	
	LOW VOLTAGE BOX	
<u></u>	TELEPHONE SOCKET OUTLET	
- N	COMPUTER PATCH PANEL	
•	JUNCTION BOX W.P.	

	REVISIONS	5
NO.	DRAWINGS	DATE
(1)		
(2)		
(3)		

Contracting Authority:

Enabel - Belgian Development Agency



Funded By:





Project Title:

"Public services contract for "Design and supervision of two schools in Beit Safafa and Al-Sheikh Saad"

Lot 1: Al-Safa school kindergarten Reference No.: PZA170421T-10044


Designed by:



Jerusalem - Sheikh Jarrah- Tobler8 email: mr.wasimhija@gmail.com

Drawing Title	Proposed TEL.& NET. System	Date: 11/2023 Scale: 1:75
Designed by:	Eng. Adli Naser AL Deen	Drawing No:
Checked by:	Eng. Midhat Al Shareef	E04
Approved by:		604
Coordinate Manager:		



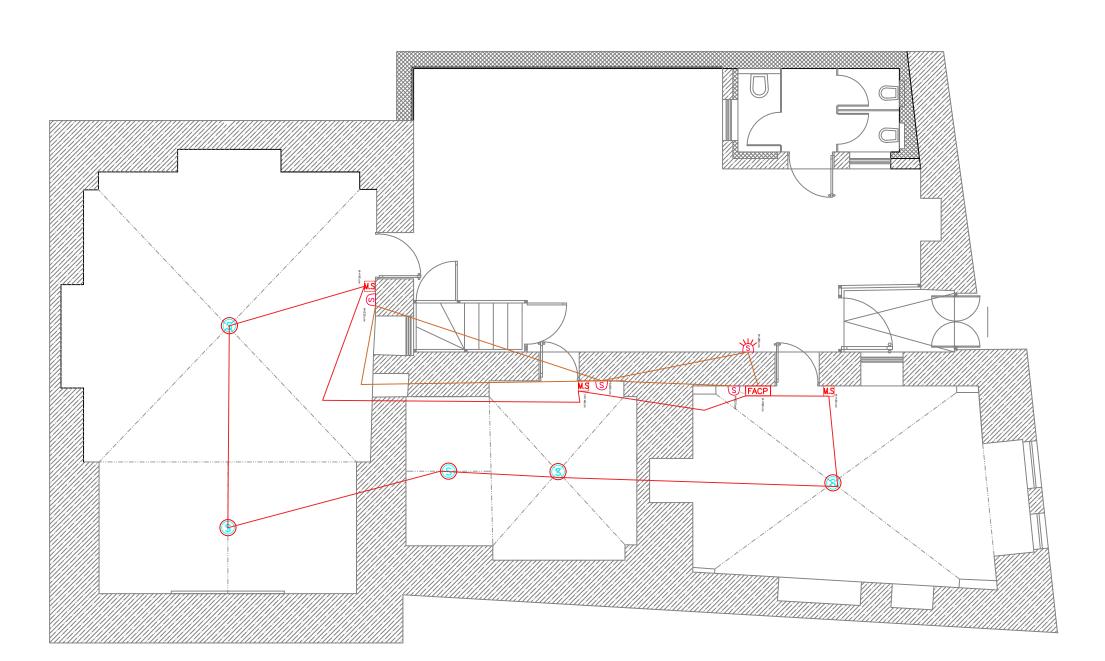

- (1) All Dimensions Are In cm.
- (2) All Levels Are In cm
- (3) Any Missing or Unclear Detail And All Fastening Systems For All Elements Shall be Approved by The Supervisor.

Legend:

SYMBOL	DESCRIPTION	
SIMBUL	FIRE ALARM SYSTEM	
<u>(S)</u>	PHOTO SMOKE SENSOR	
M.S	BREAK GLASS	
ত	internal siren	
烝	EXTERNAL SIREN WITH FALSHER	
FACP	FIRE ALARM CONTROL PANEL	

	REVISIONS	i
NO.	DRAWINGS	DATE
(1)		
(2)		
(3)		

Contracting Authority:

Enabel - Belgian Development Agency



Funded By:





Project Title:

"Public services contract for "Design and supervision of two schools in Beit Safafa and Al-Sheikh Saad"

Lot 1: Al-Safa school kindergarten Reference No.: PZA170421T-10044

Designed by:



Jerusalem - Sheikh Jarrah- Tobler8 email: mr.wasimhija@gmail.com

Drawing Title	Proposed FIRE ALARM SYSTEM	Date: 11/2023 Scale: 1:75
Designed by:	Eng. Adli Naser AL Deen	Drawing No:
Checked by:	Eng. Midhat Al Shareef	E05
Approved by:		7 503
Coordinate Manager:		1



25W WALL MOUNTED ADJUSTABLE HORN



Notes

- (1) All Dimensions Are In cm.
- (2) All Levels Are In cm
- (3) Any Missing or Unclear Detail And All Fastening Systems For All Elements Shall be Approved by The Supervisor.

Legend:

SYMBOL	DESCRIPTION	
SIMBUL	SOUND SYSTEM	
<u></u>	WALL MOUNTED ADJUSTABLE HORN SPEAKER IP65	
\Box	6WATT RECESSED LOUD SPEAKER	
PAVA	PUBLIC ADDRESS AND VOICE ALARM RACK	
•	XLR connection socket	

	REVISIONS	i .
NO.	DRAWINGS	DATE
(1)		
(2)		
(3)		

Contracting Authority:

Enabel - Belgian Development Agency



Funded By:





Belgium partner in development

Project Title:

"Public services contract for "Design and supervision of two schools in Beit Safafa and Al-Sheikh Saad"


Lot 1: Al-Safa school kindergarten Reference No.: PZA170421T-10044

Designed by:



Jerusalem - Sheikh Jarrah- Tobler8 email: mr.wasimhija@gmail.com

	Drawing Title	Proposed SOUND SYSTEM	11/2023 Scale: 1:75
	Designed by:	Eng. Adli Naser AL Deen	Drawing No:
	Checked by:	Eng. Midhat Al Shareef	E06
l	Approved by:		7
l	Coordinate Manager:		1

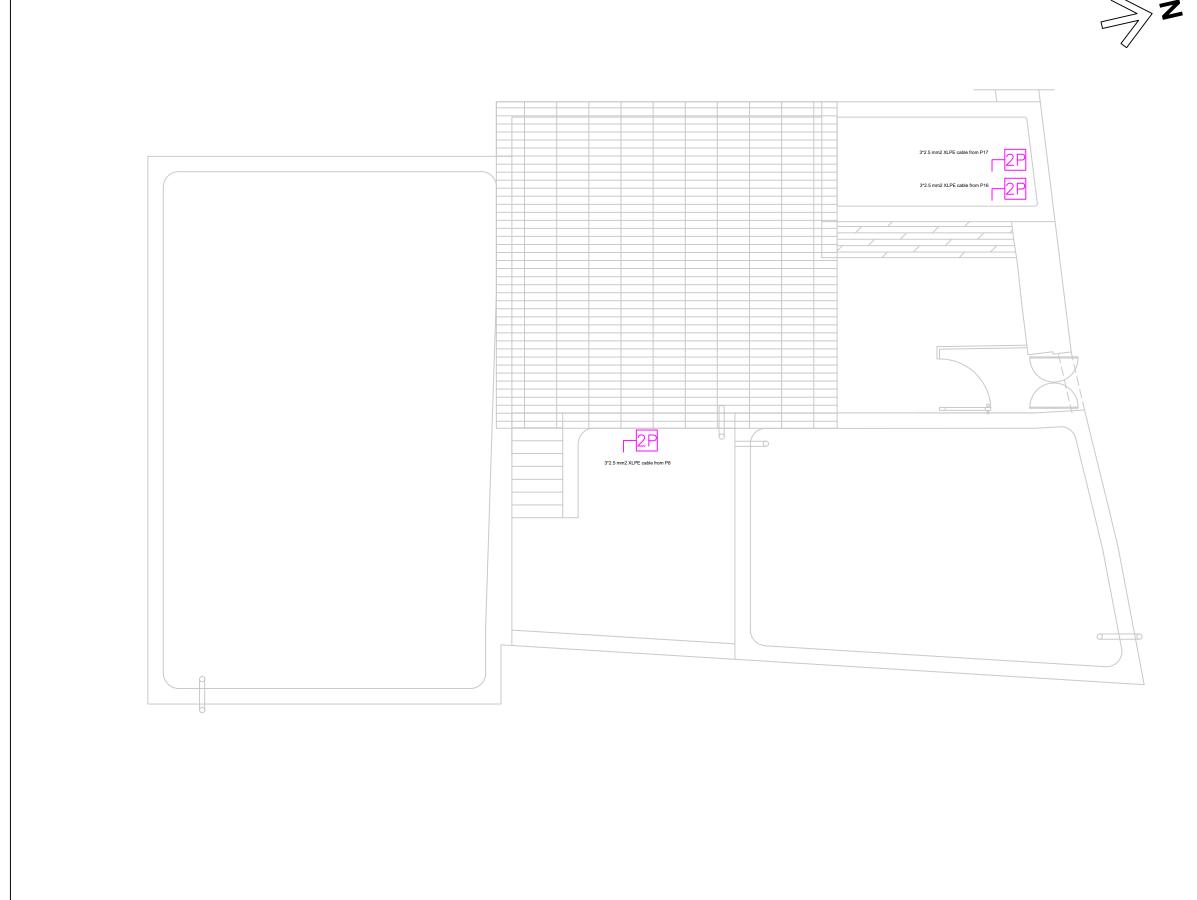

- (1) All Dimensions Are In cm.
- (2) All Levels Are In cm
- (3) Any Missing or Unclear Detail And All Fastening Systems For All Elements Shall be Approved by The Supervisor.

Legend:

SYMBOL	DESCRIPTION	
<u>-2P</u>	SINGLE PHASE (2POLE) ISOLATOR, Rate As Indicated	

	REVISIONS	ò
NO.	DRAWINGS	DATE
(1)		
(2)		
(3)		

Contracting Authority:

Enabel - Belgian Development Agency



Funded By:





Project Title:

"Public services contract for "Design and supervision of two schools in Beit Safafa and Al-Sheikh Saad"

Lot 1: Al-Safa school kindergarten Reference No.: PZA170421T-10044

Designed by:



Jerusalem - Sheikh Jarrah- Tobler8 email: mr.wasimhija@gmail.com

Drowing Burney Boos			Date:
Drawing Title	Proposed ROOF POWER	1	11/2023 Scale: 1:75
Designed by:	Eng. Adli Naser AL Deen		Drawing No:
Checked by:	Eng. Midhat Al Shareef		E07
Approved by:			[607
Coordinate Manager		\neg	



5*10 XLPE CABLE TO KWH.DB

1x16A 、[₺] 1x16A 、

sp.

3X43A

1x25A

1X10A } 1X10A } 1X10A }

Ľ2

L3

Light

RCD 2*25A 0.03A

1X10A 71X10A

MDB

1x16A 🎍 1x16A 🎍 1x16A

3*2.5 XLPE CABLE

3*2.5 XIPE CABLE

3X32A

1x16A 、

Power

RCD 4*40A 0.03A



Notes

- (1) All Dimensions Are In cm.
- (2) All Levels Are In cm
- (3) Any Missing or Unclear Detail And All Fastening Systems For All Elements Shall be Approved by The Supervisor.

Legend:

DESCRIPTION	_
SINGLE PHASE (2POLE) ISOLATOR, Rate As indicated	_
	+
	\Box
	╛
	\dashv
	╛
	4

	REVISIONS	
NO.	DRAWINGS	DATE
(1)		
(2)		
(3)		

Contracting Authority:

Enabel - Belgian Development Agency



Funded By:





Project Title:

"Public services contract for "Design and supervision of two schools in Beit Safafa and Al-Sheikh Saad"


Lot 1: Al-Safa school kindergarten Reference No.: PZA170421T-10044

Designed by:



Jerusalem - Sheikh Jarrah- Tobler8 email: mr.wasimhija@gmail.com

Drawing Title	Proposed MDB	Date: 11/2023 Scale: 1:75
Designed by:	Eng. Adli Naser AL Deen	Drawing No:
Checked by:	Eng. Midhat Al Shareef	E08
Approved by:		602
Coordinate Manager:		

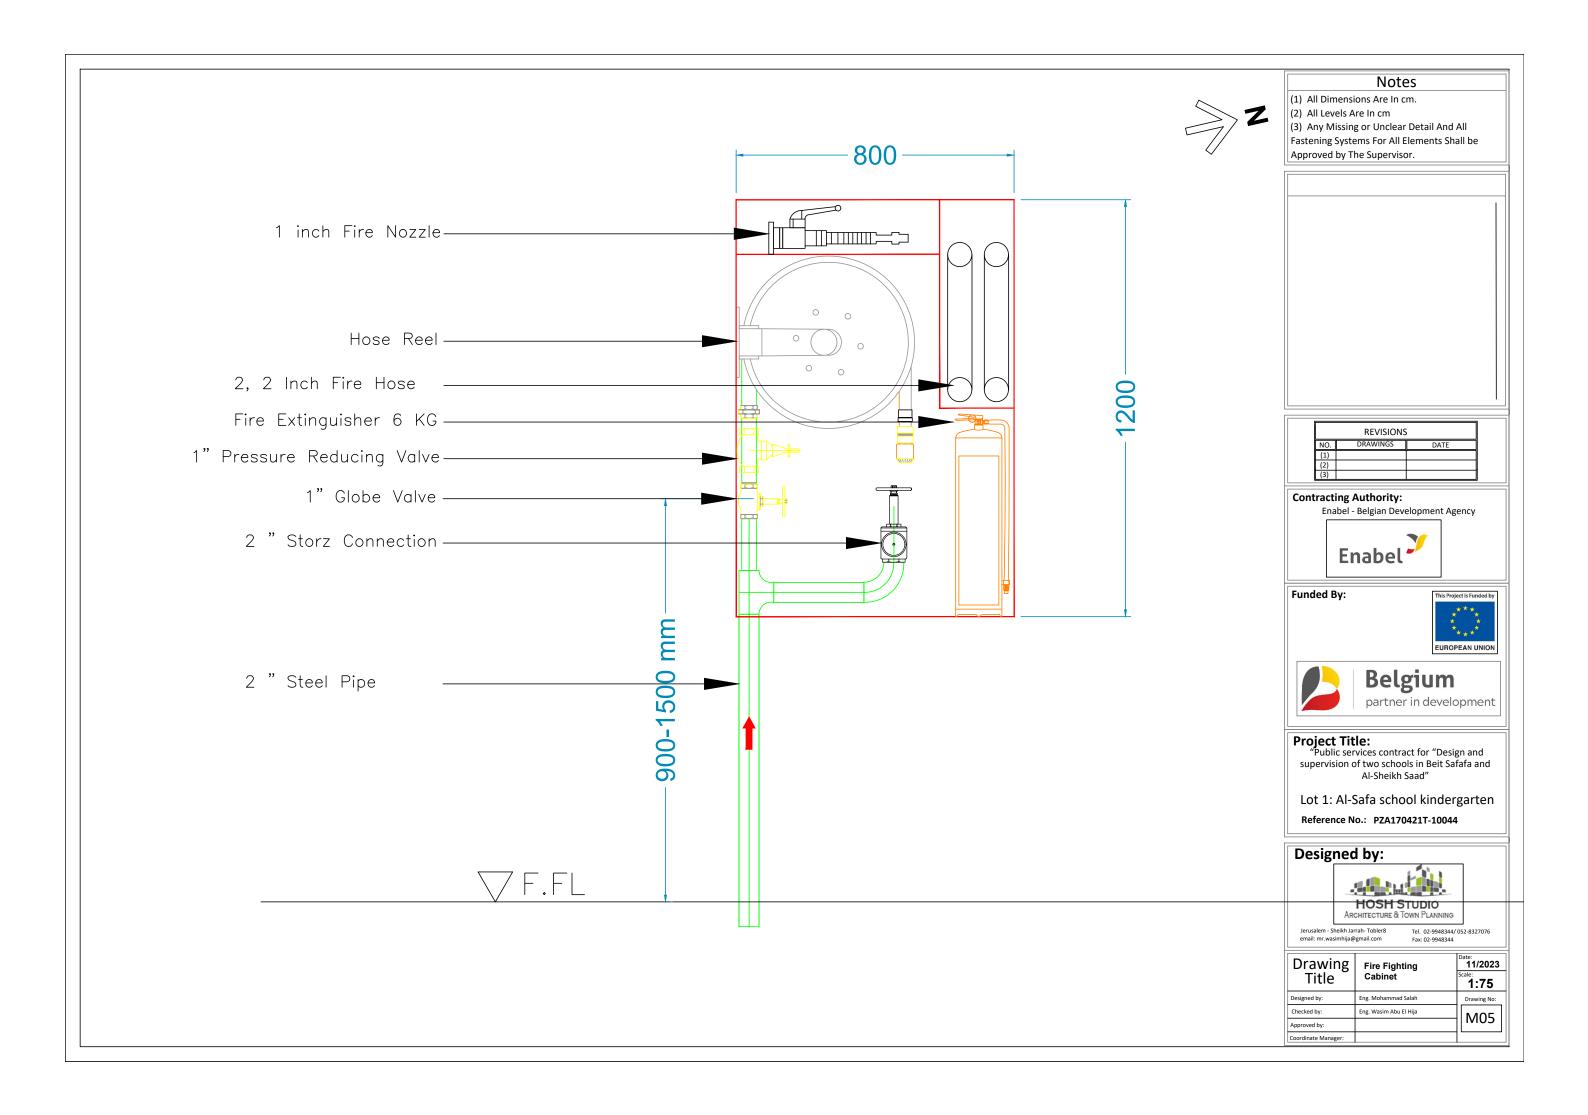

Public services contract for

"THE CREATION OF AL-SAFA KINDERGARTEN AND THE REHABILITATION OF AL-SAFA BASIC SCHOOL IN BEIT SAFAFA"

Reference No.: PZA170421T-10055

Al Safa Basic School

Electrical Drawings


Designed by

ARCHITECTURE & TOWN PLANNING







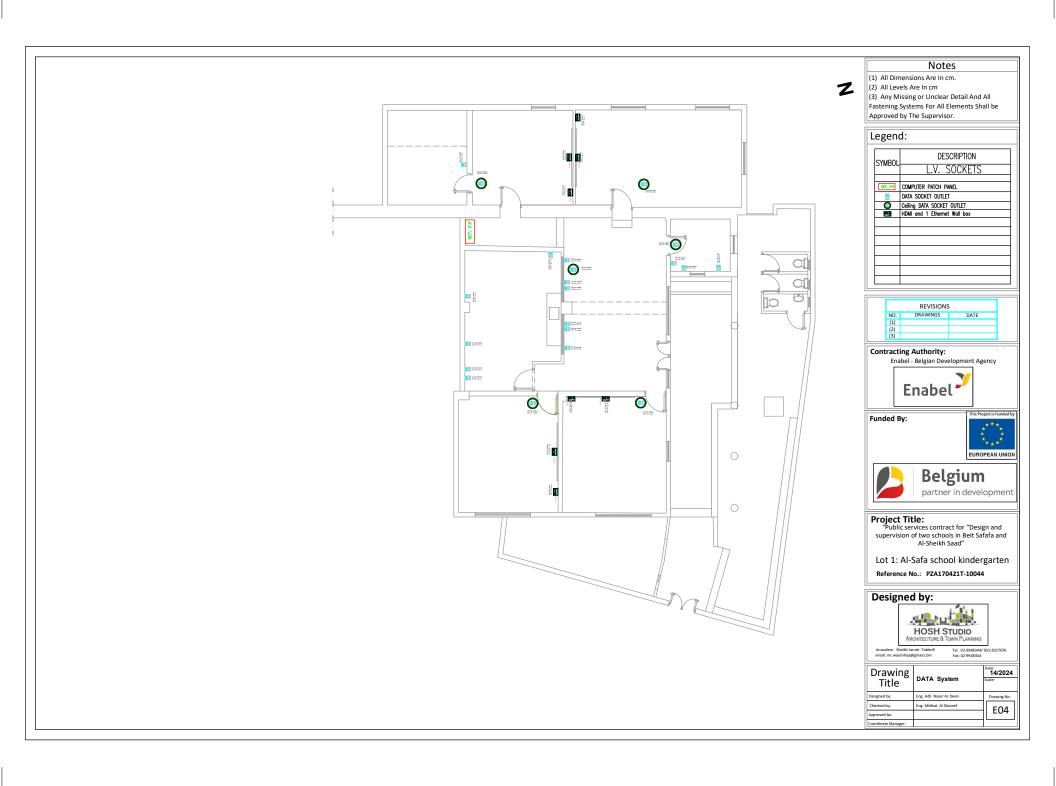



Notes

- (1) All Dimensions Are In cm.
- (2) All Levels Are In cm
 (3) Any Missing or Unclear Detail And All Fastening Systems For All Elements Shall be Approved by The Supervisor.

Legend:

SYMBOL	DESCRIPTION
STINIDOL	FIRE ALARM SYSTEM
S	PHOTO SMOKE SENSOR
M.S	BREAK GLASS
(HD)	HEAT DETECTOR
isi	EXTERNAL SIREN WITH FALSHER
<u>©</u>	internal siren
FACP	FIRE ALARM CONTROL PANEL

	REVISIONS				
NO.	DRAWINGS	DATE			
(1)					
(2)					
(3)					

Contracting Authority:

Enabel - Belgian Development Agency



Funded By:





Belgium partner in development

Project Title:
"Public services contract for "Design and supervision of two schools in Beit Safafa and Al-Sheikh Saad"

Lot 1: Al-Safa school kindergarten

Reference No.: PZA170421T-10044


Designed by:




Jerusalem - Sheikh Jarrah- Tobler8 email: mr.wasimhija@gmail.com

Drawing Title	Fire Alarm System	Date: 1/2024 Scale:
Designed by:	Eng. Adli Naser AL Deen	Drawing No:
Checked by:	Eng. Midhat Al Shareef	E05
Approved by:		7 503
Coordinate Manager:		



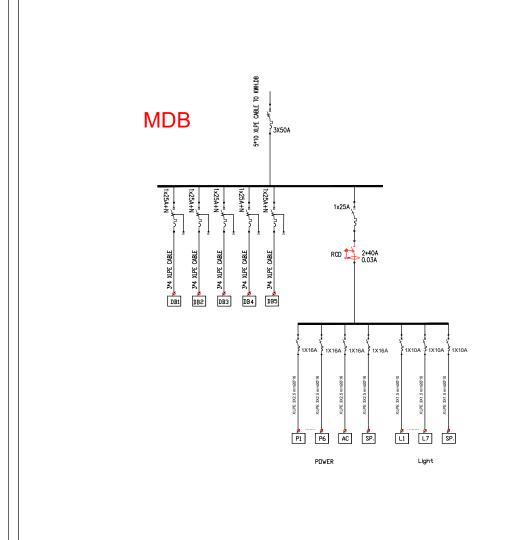

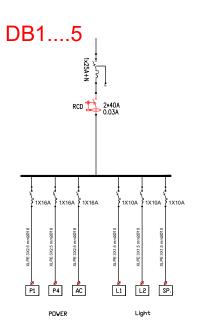

Notes

- (1) All Dimensions Are In cm.
- (2) All Levels Are In cm
- (3) Any Missing or Unclear Detail And All Fastening Systems For All Elements Shall be Approved by The Supervisor.

Legend:



	REVISIONS				
NO.	DRAWINGS	DATE			
(1)					
(2)					
(3)					

Contracting Authority:

Enabel - Belgian Development Agency



Funded By:





Project Title:

"Public services contract for "Design and supervision of two schools in Beit Safafa and Al-Sheikh Saad"


Lot 1: Al-Safa school kindergarten


Reference No.: PZA170421T-10044

Designed by:




Drawing Title	ELECTRICAL BOARD DIAGRAMS	Date: 1/2024 Scale:
Designed by:	Eng. Adli Naser AL Deen	Drawing No:
Checked by:	Eng. Midhat Al Shareef	F07
Approved by:		7 507

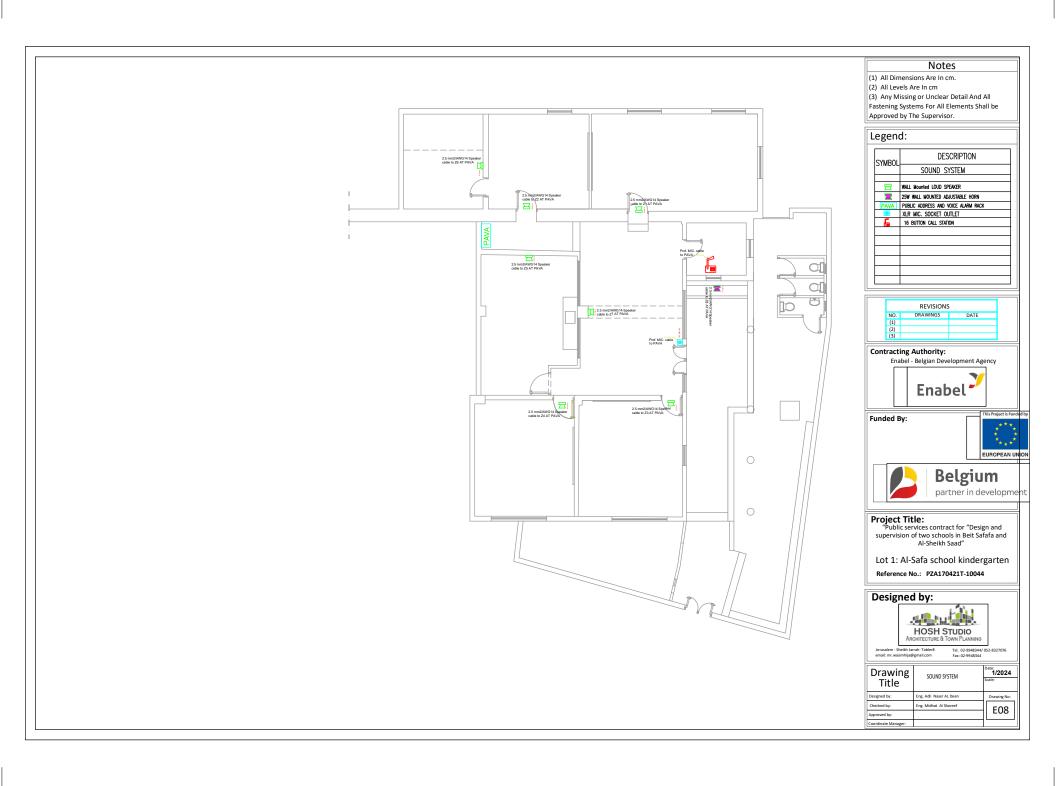

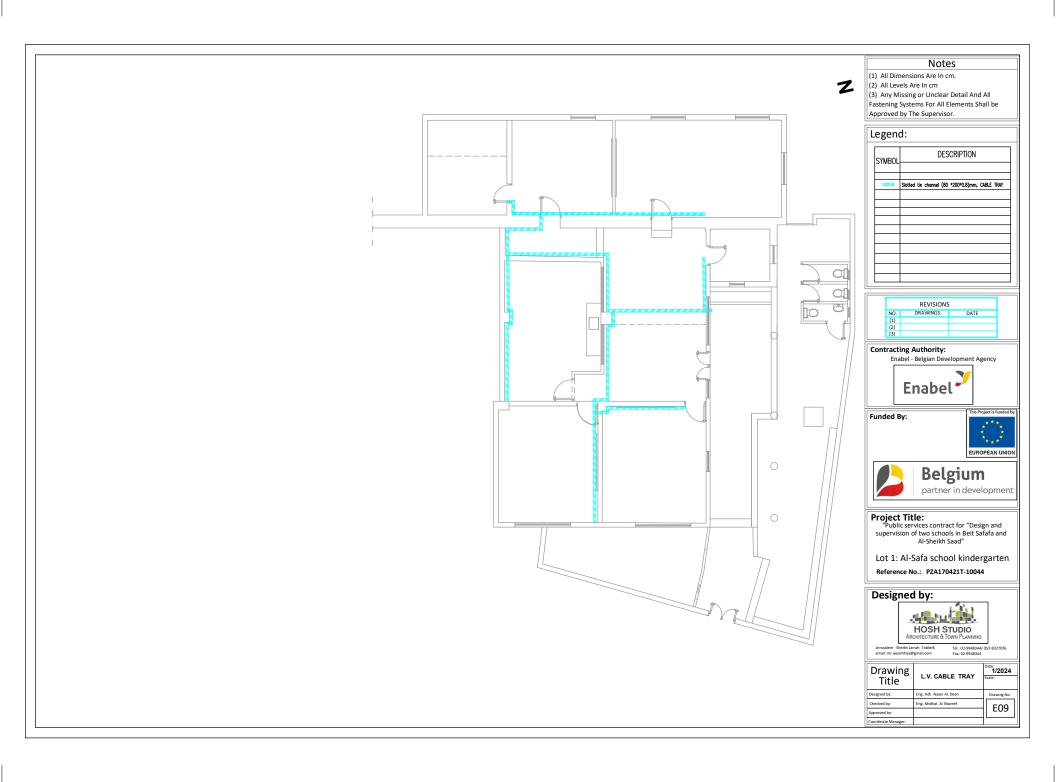



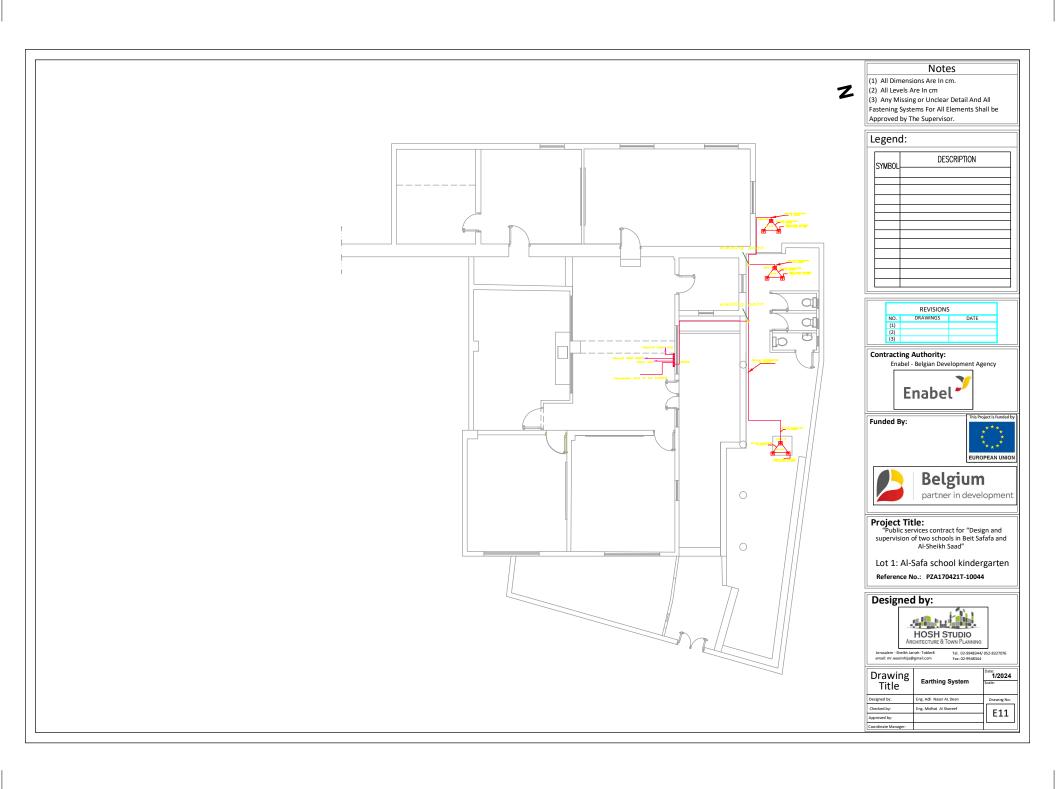

Public services contract for "Public services contract for

"THE CREATION OF AL-SAFA KINDERGARTEN AND THE REHABILITATION OF AL-SAFA BASIC SCHOOL IN BEIT SAFAFA"


Reference No.: PZA170421T-10055

Al Safa Basic School

Mechanical Drawings

Designed by



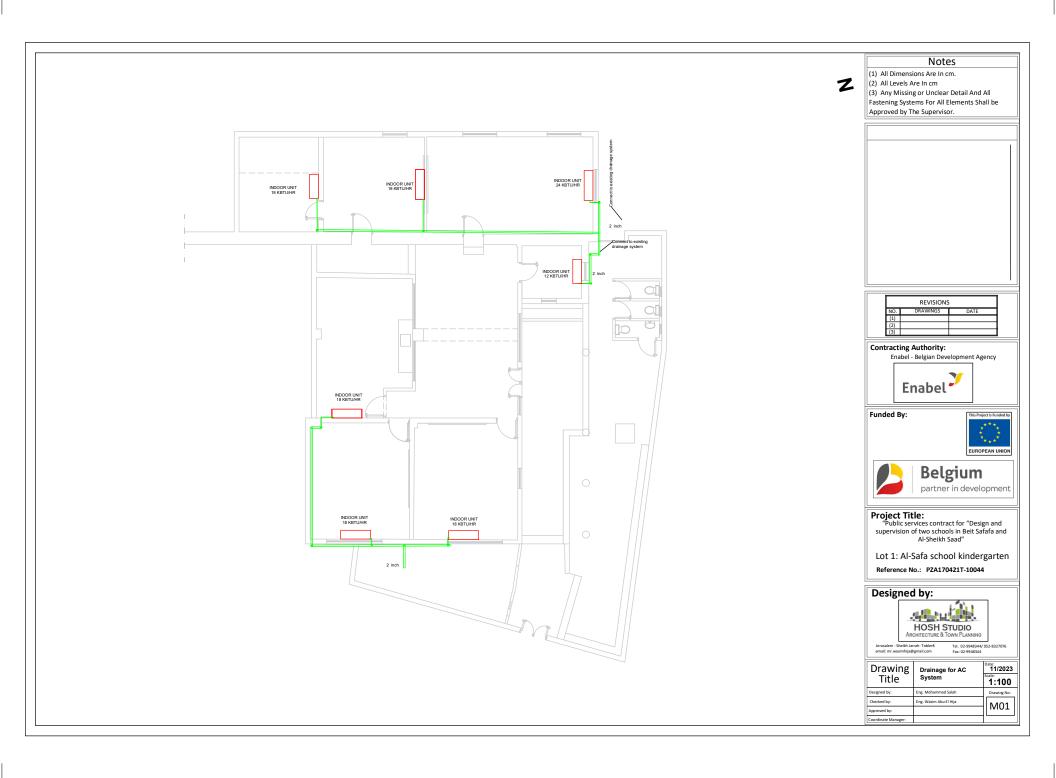



Notes

(1) All Dimensions Are In cm. (2) All Levels Are In cm

(3) Any Missing or Unclear Detail And All Fastening Systems For All Elements Shall be Approved by The Supervisor.

			Т

Г	REVISIONS		
NO.	DRAWINGS	DATE	
(1)			
(2)			
(3)			

Contracting Authority: Enabel - Belgian Development Agency



Funded By:





Project Title:

"Public services contract for "Design and supervision of two schools in Beit Safafa and Al-Sheikh Saad"

Lot 1: Al-Safa school kindergarten

Reference No.: PZA170421T-10044

Designed by:



Drawing Title	Ventilation and Air Conditioning System	1/2024 Scale: 1:100
Designed by:	Eng. Mohammad Salah	Drawing No:
Checked by:	Eng. Wasim Abu El Hija	M02
Approved by:		1 10102
Coordinate Manager:		1